GENERAL NOTES

- 1. THESE DOCUMENTS AND COPIES THEREOF ARE LEGAL INSTRUMENTS OF SERVICE FOR USE BY THE OWNER AND AUTHORIZED AGENTS FOR THE DESIGNATED PROPERTY ONLY.
- 2. ALL TRADES SHALL BE RESPONSIBLE FOR KNOWLEDGE OF RELATIVE INFORMATION CONTAINED IN THESE DOCUMENTS AND THE CONDITIONS UNDER WHICH THEY WILL BE EXPECTED TO PERFORM.
- 3. THE CONTRACTOR SHALL VISIT THE SITE PRIOR TO BIDDING OR COMMENCEMENT OF CONSTRUCTION AND VERIFY ALL EXISTING CONDITIONS SHOWN ON THESE DRAWING ARE PERTINENT TO THE WORK DESCRIBED HEREIN.
- 4. THE LANDSCAPE ARCHITECT SHALL BE NOTIFIED IMMEDIATELY SHOULD ANY CONDITION ARISE WHERE THE INTENT OF THE DRAWINGS IS IN DOUBT OR THERE IS A DISCREPANCY BETWEEN THE CONSTRUCTION DOCUMENTS AND THE FIELD CONDITIONS.
- 5. ALL CONSTRUCTION SHALL CONFORM TO THE CURRENT BUILDING CODES AND ALL LAWS AND ORDINANCES OF THE GOVERNING AGENCIES.
- 6. DO NOT SCALE DRAWINGS. VERIFY DIMENSIONS WITH THE LANDSCAPE ARCHITECT.
- 7. ANY DISCREPANCY BETWEEN THE VARIOUS DRAWINGS SHALL IMMEDIATELY BE BROUGHT TO THE ATTENTION OF THE LANDSCAPE ARCHITECT FOR CLARIFICATION.
- THE CONTRACTOR SHALL VERIFY CONSTRUCTION ACCESS, STAGING, EQUIPMENT AND VEHICLE PARKING AND WORKER BREAK AREA LOCATIONS WITH THE OWNER'S REPRESENTATIVE PRIOR TO BEGINNING THE WORK.
- ALL ITEMS TO BE REMOVED AND RELOCATED OR REPLACED SHALL BE HANDLED WITH PROPER CARE AND STORED IN A SAFE PLACE TO PREVENT DAMAGE. DAMAGED ITEMS SHOWN TO BE SALVAGED SHALL BE REPLACED AT THE CONTRACTOR'S EXPENSE.
- 10. THE CONTRACTOR SHALL KEEP ALL TRASH, MATERIALS AND EQUIPMENT INSIDE THE WORK AREA AND AWAY FROM WALKWAYS AND ROADWAYS.
- 11. <u>CAUTION</u>: BEFORE EXCAVATING, VERIFY THE LOCATION OF UNDERGROUND UTILITIES. AT LEAST TWO (2) WORKING DAYS PRIOR TO EXCAVATION, THE CONTRACTOR SHALL REQUEST MARK OUT OF UNDERGROUND UTILITIES.

EXISTING SLOPE

12. PRIOR TO START OF WORK, SCHEDULE A SITE MEETING WITH THE LANDSCAPE ARCHITECT TO IDENTIFY LIMITS OF WORK, LANDSCAPE REMOVALS AND METHODS OF PLANT PROTECTION.

DEFERRED SUBMITTALS


- SPA & EQUIPMENT
 FITNESS EQUIPMENT
- 3. TRASH ENCLOSURE

SITE PLAN


MACKINAW HOTEL

PRIVATE LANDSCAPE IMPROVEMENTS
3001 JACQUIER RD
CITY PLACERVILLE, CA 95667

HWY 50

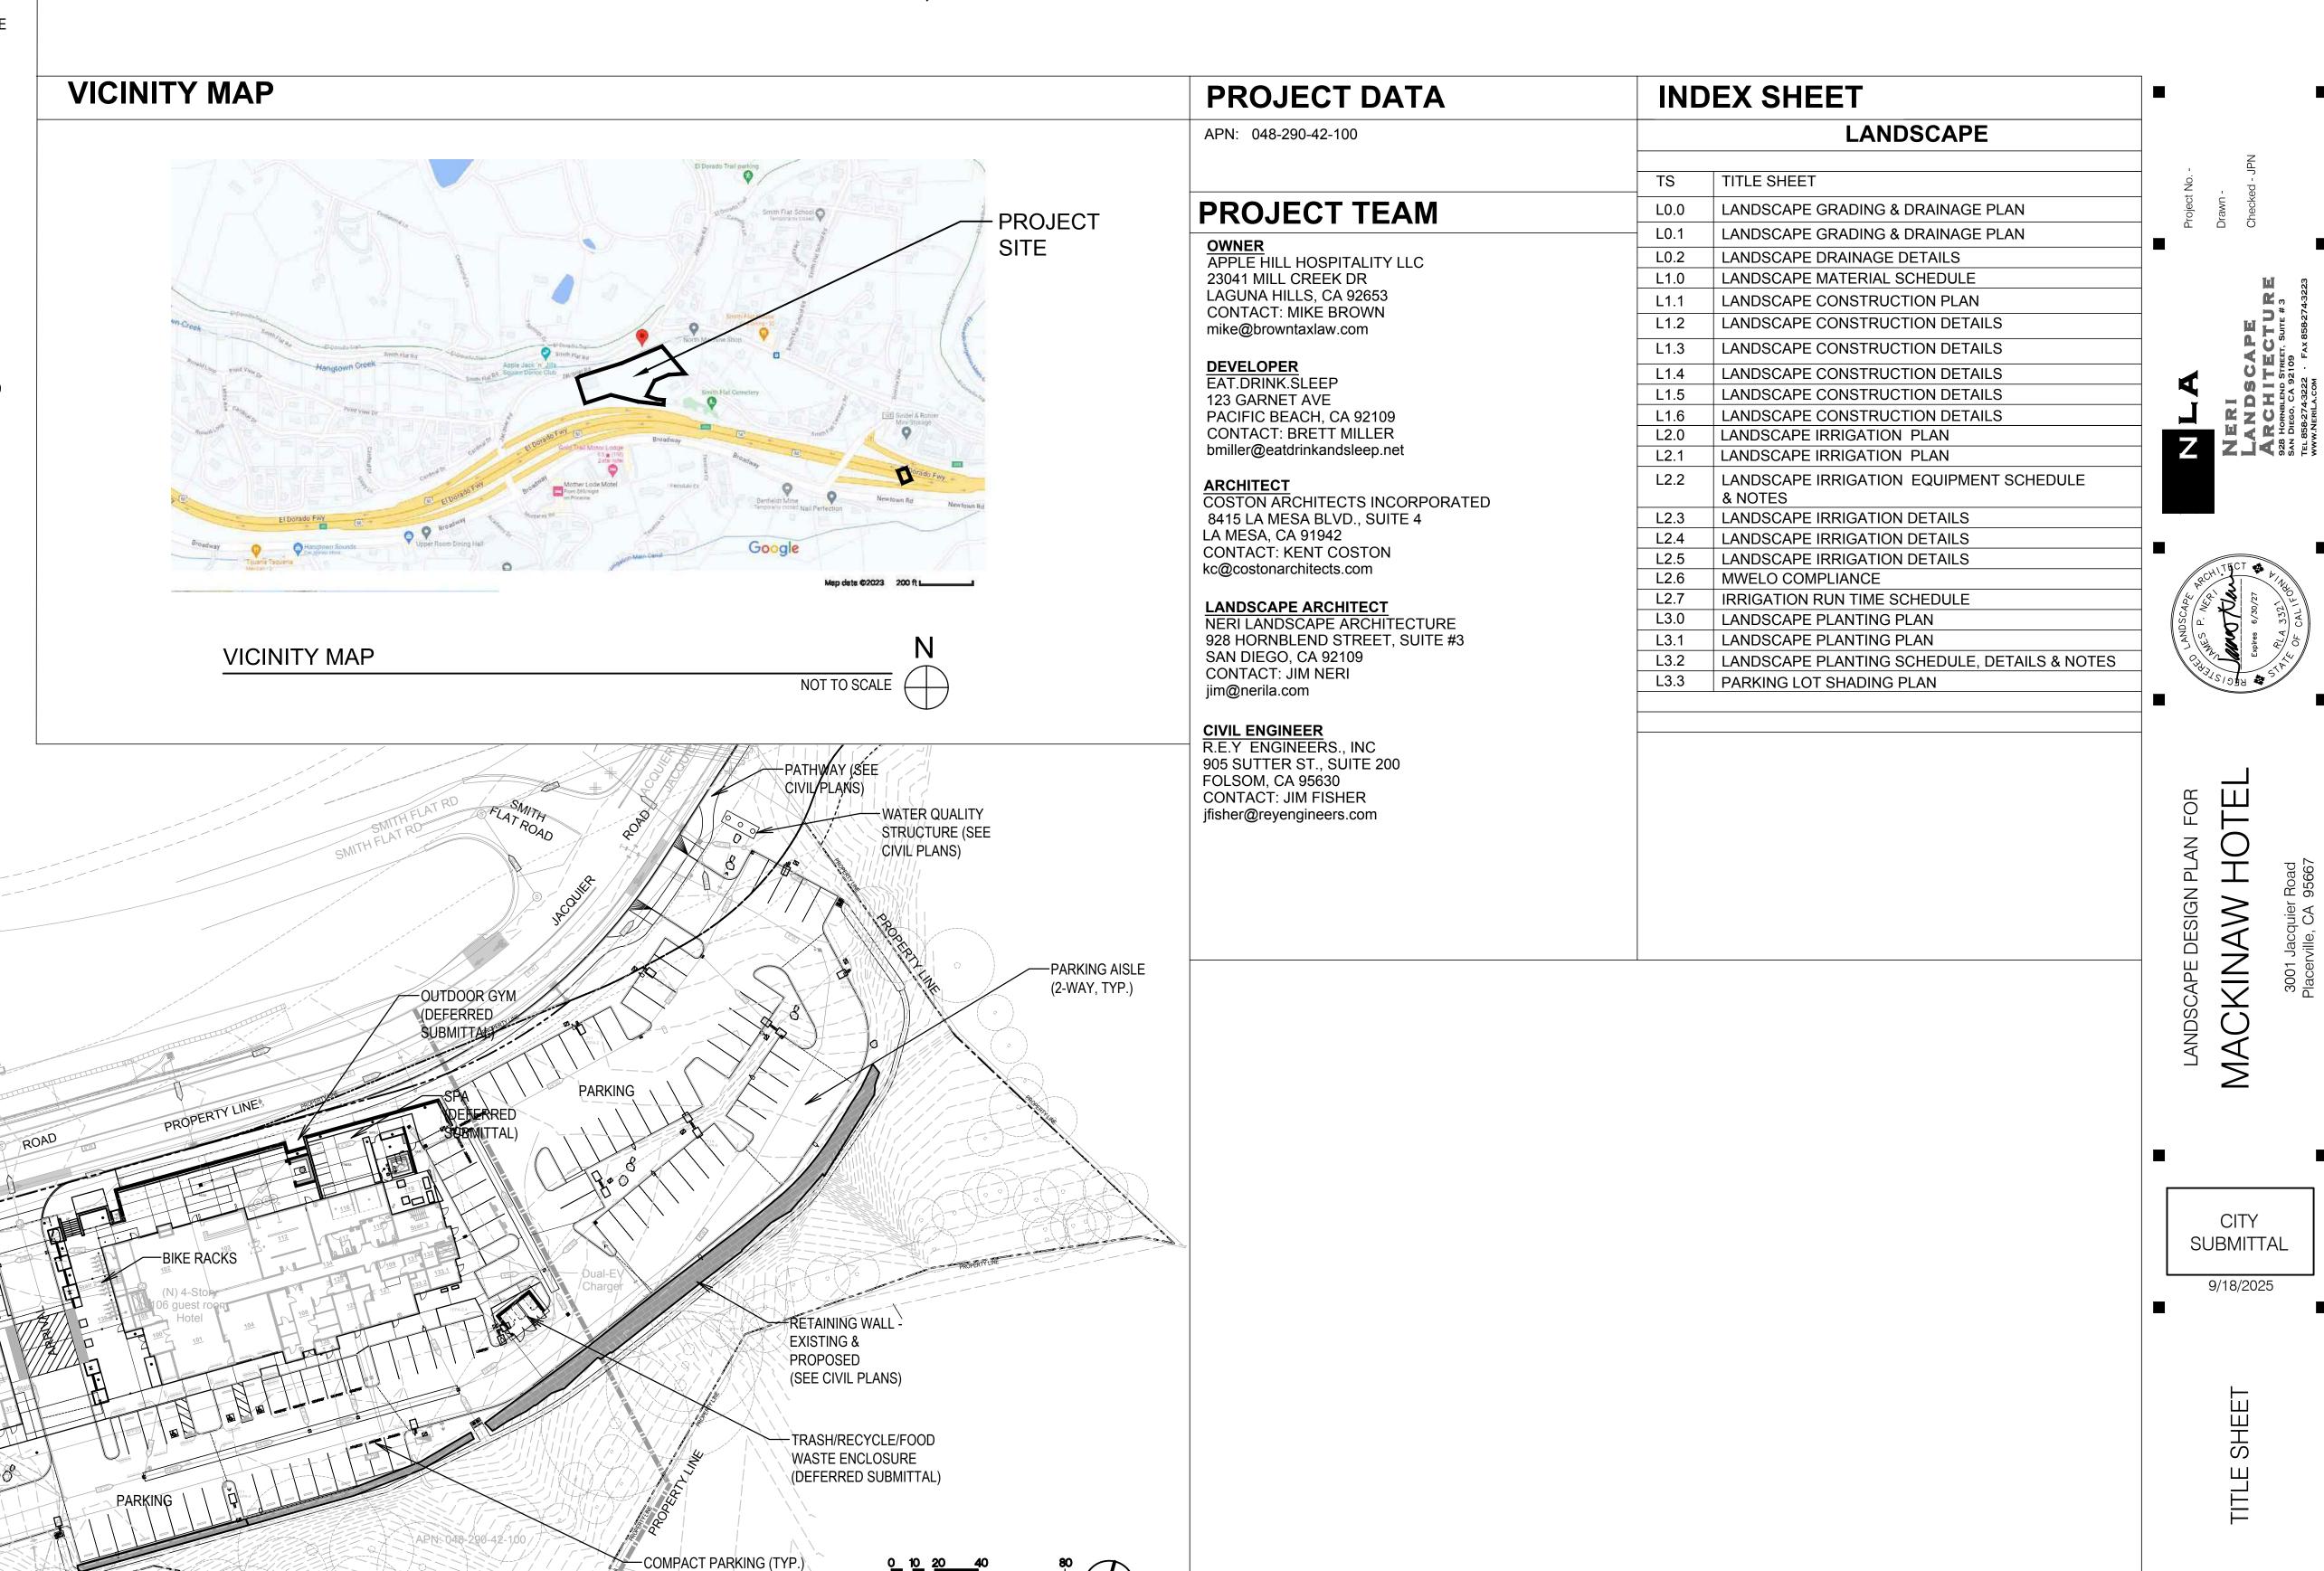




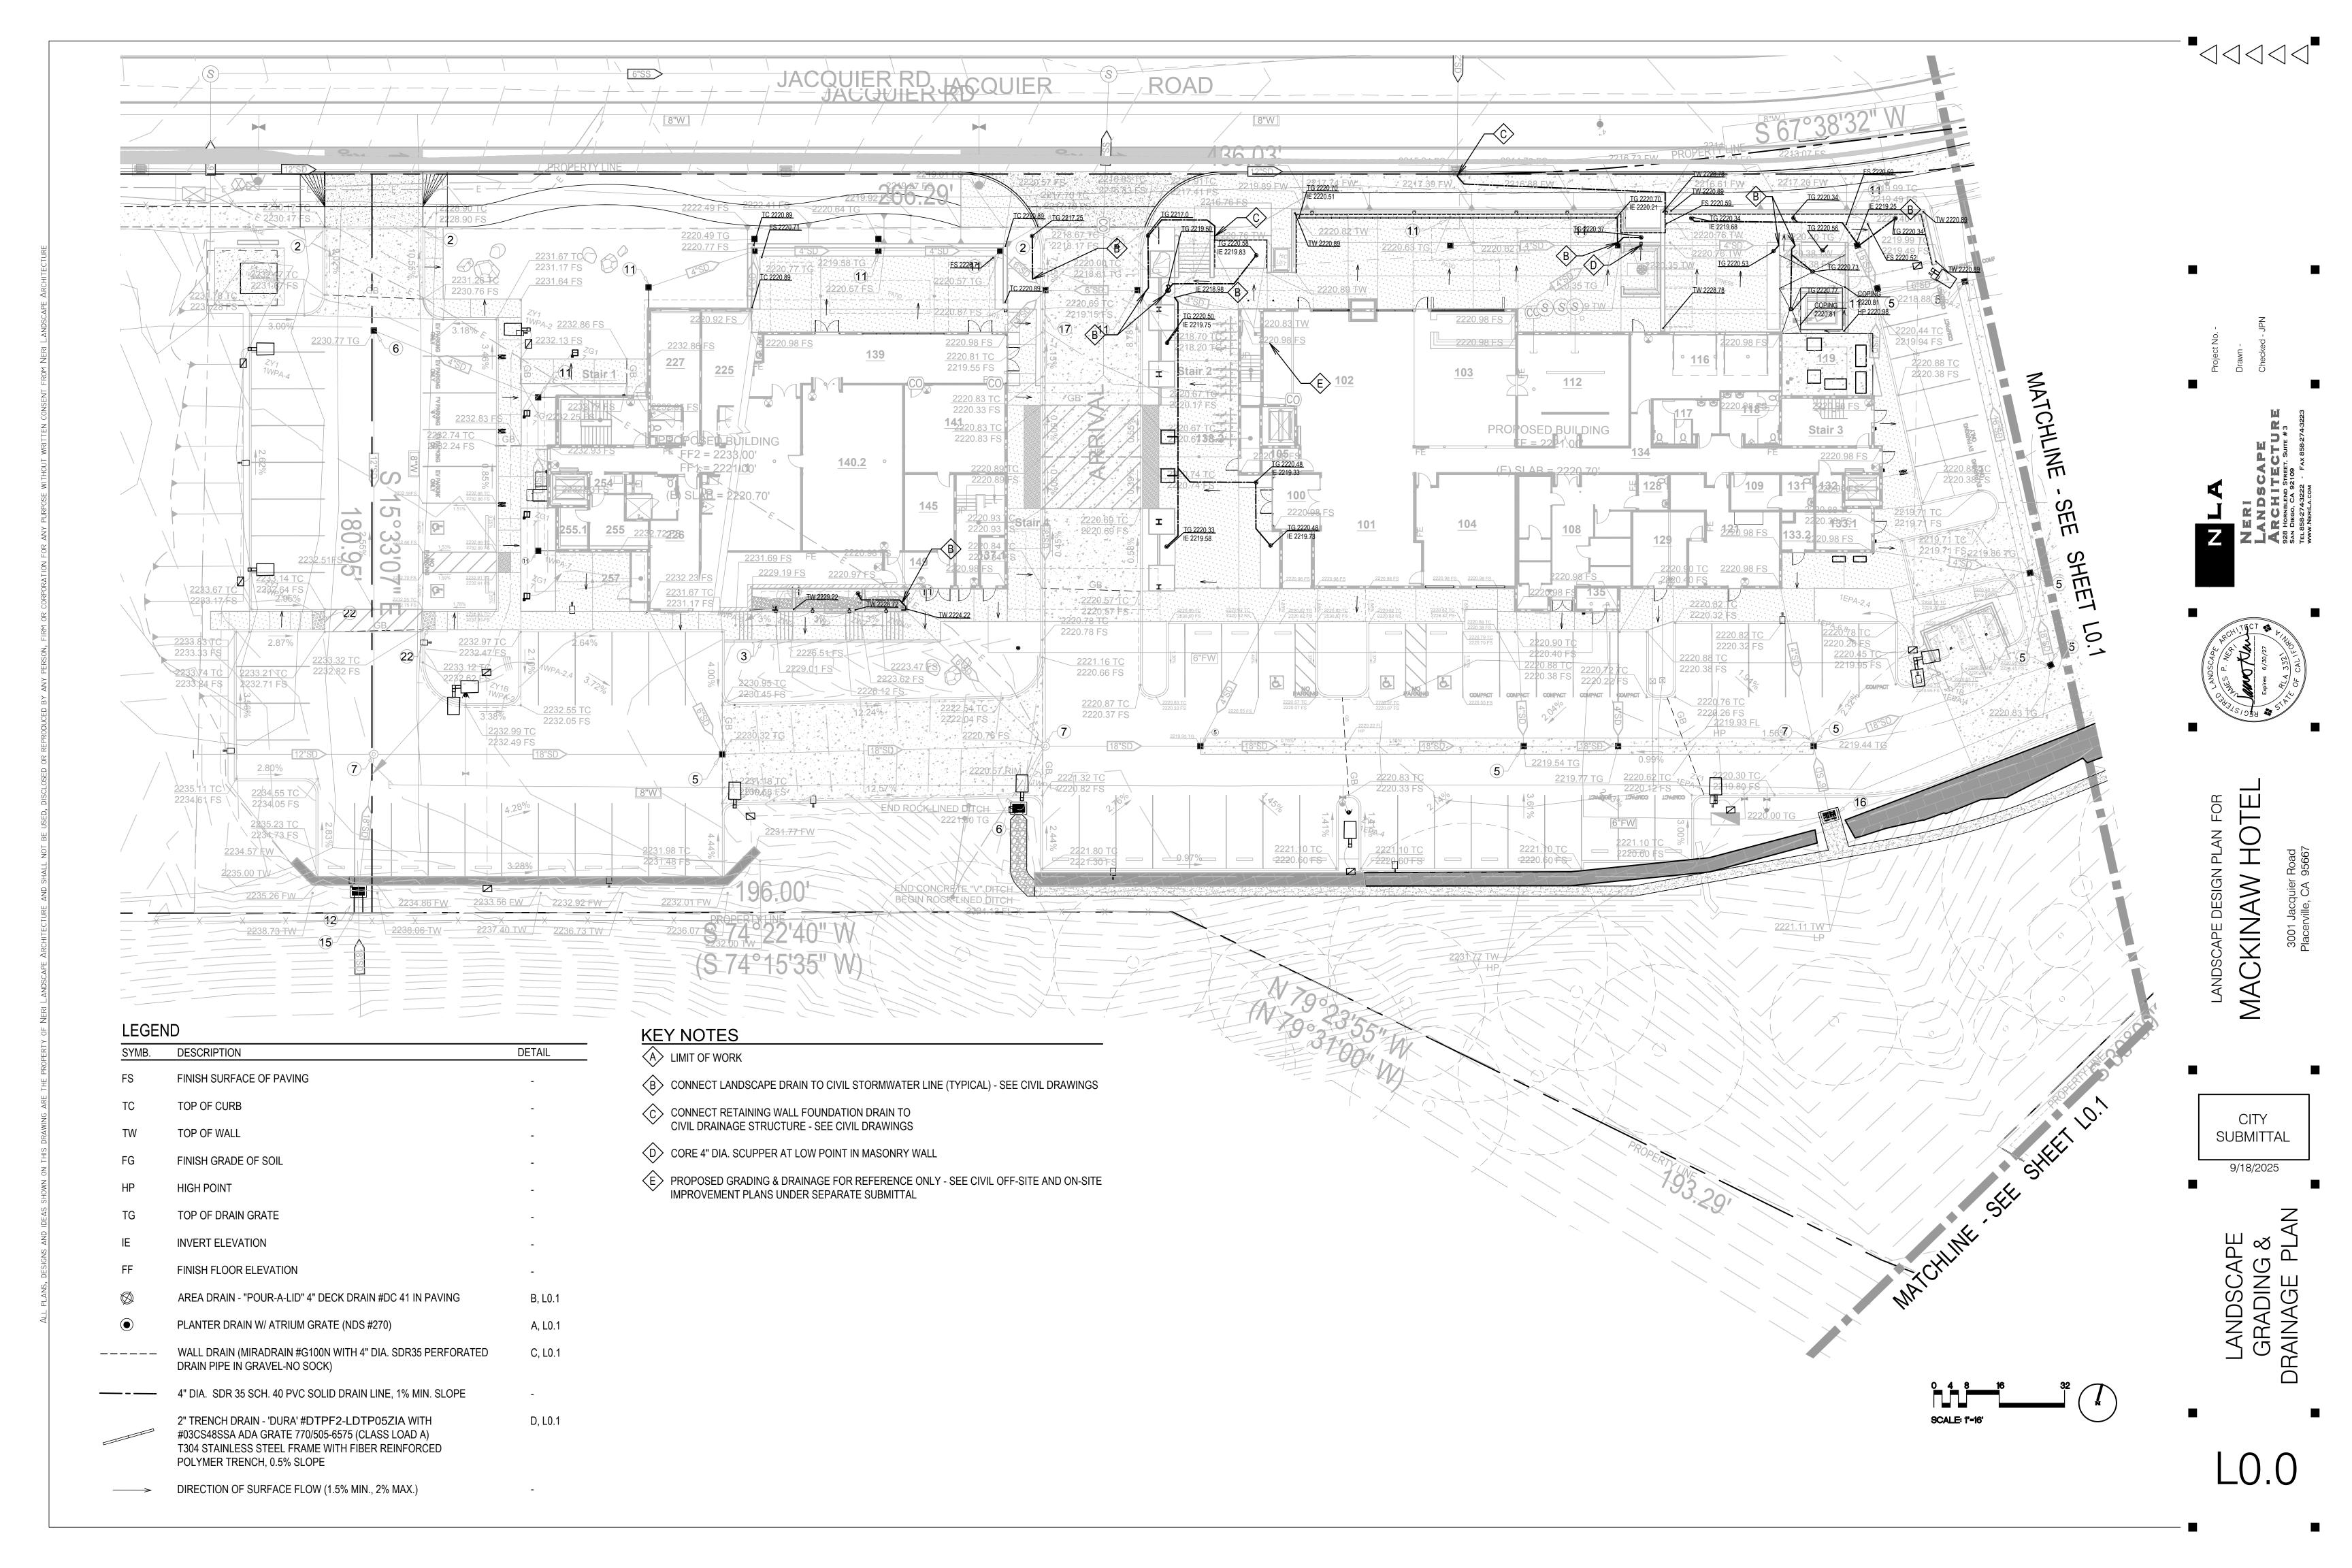






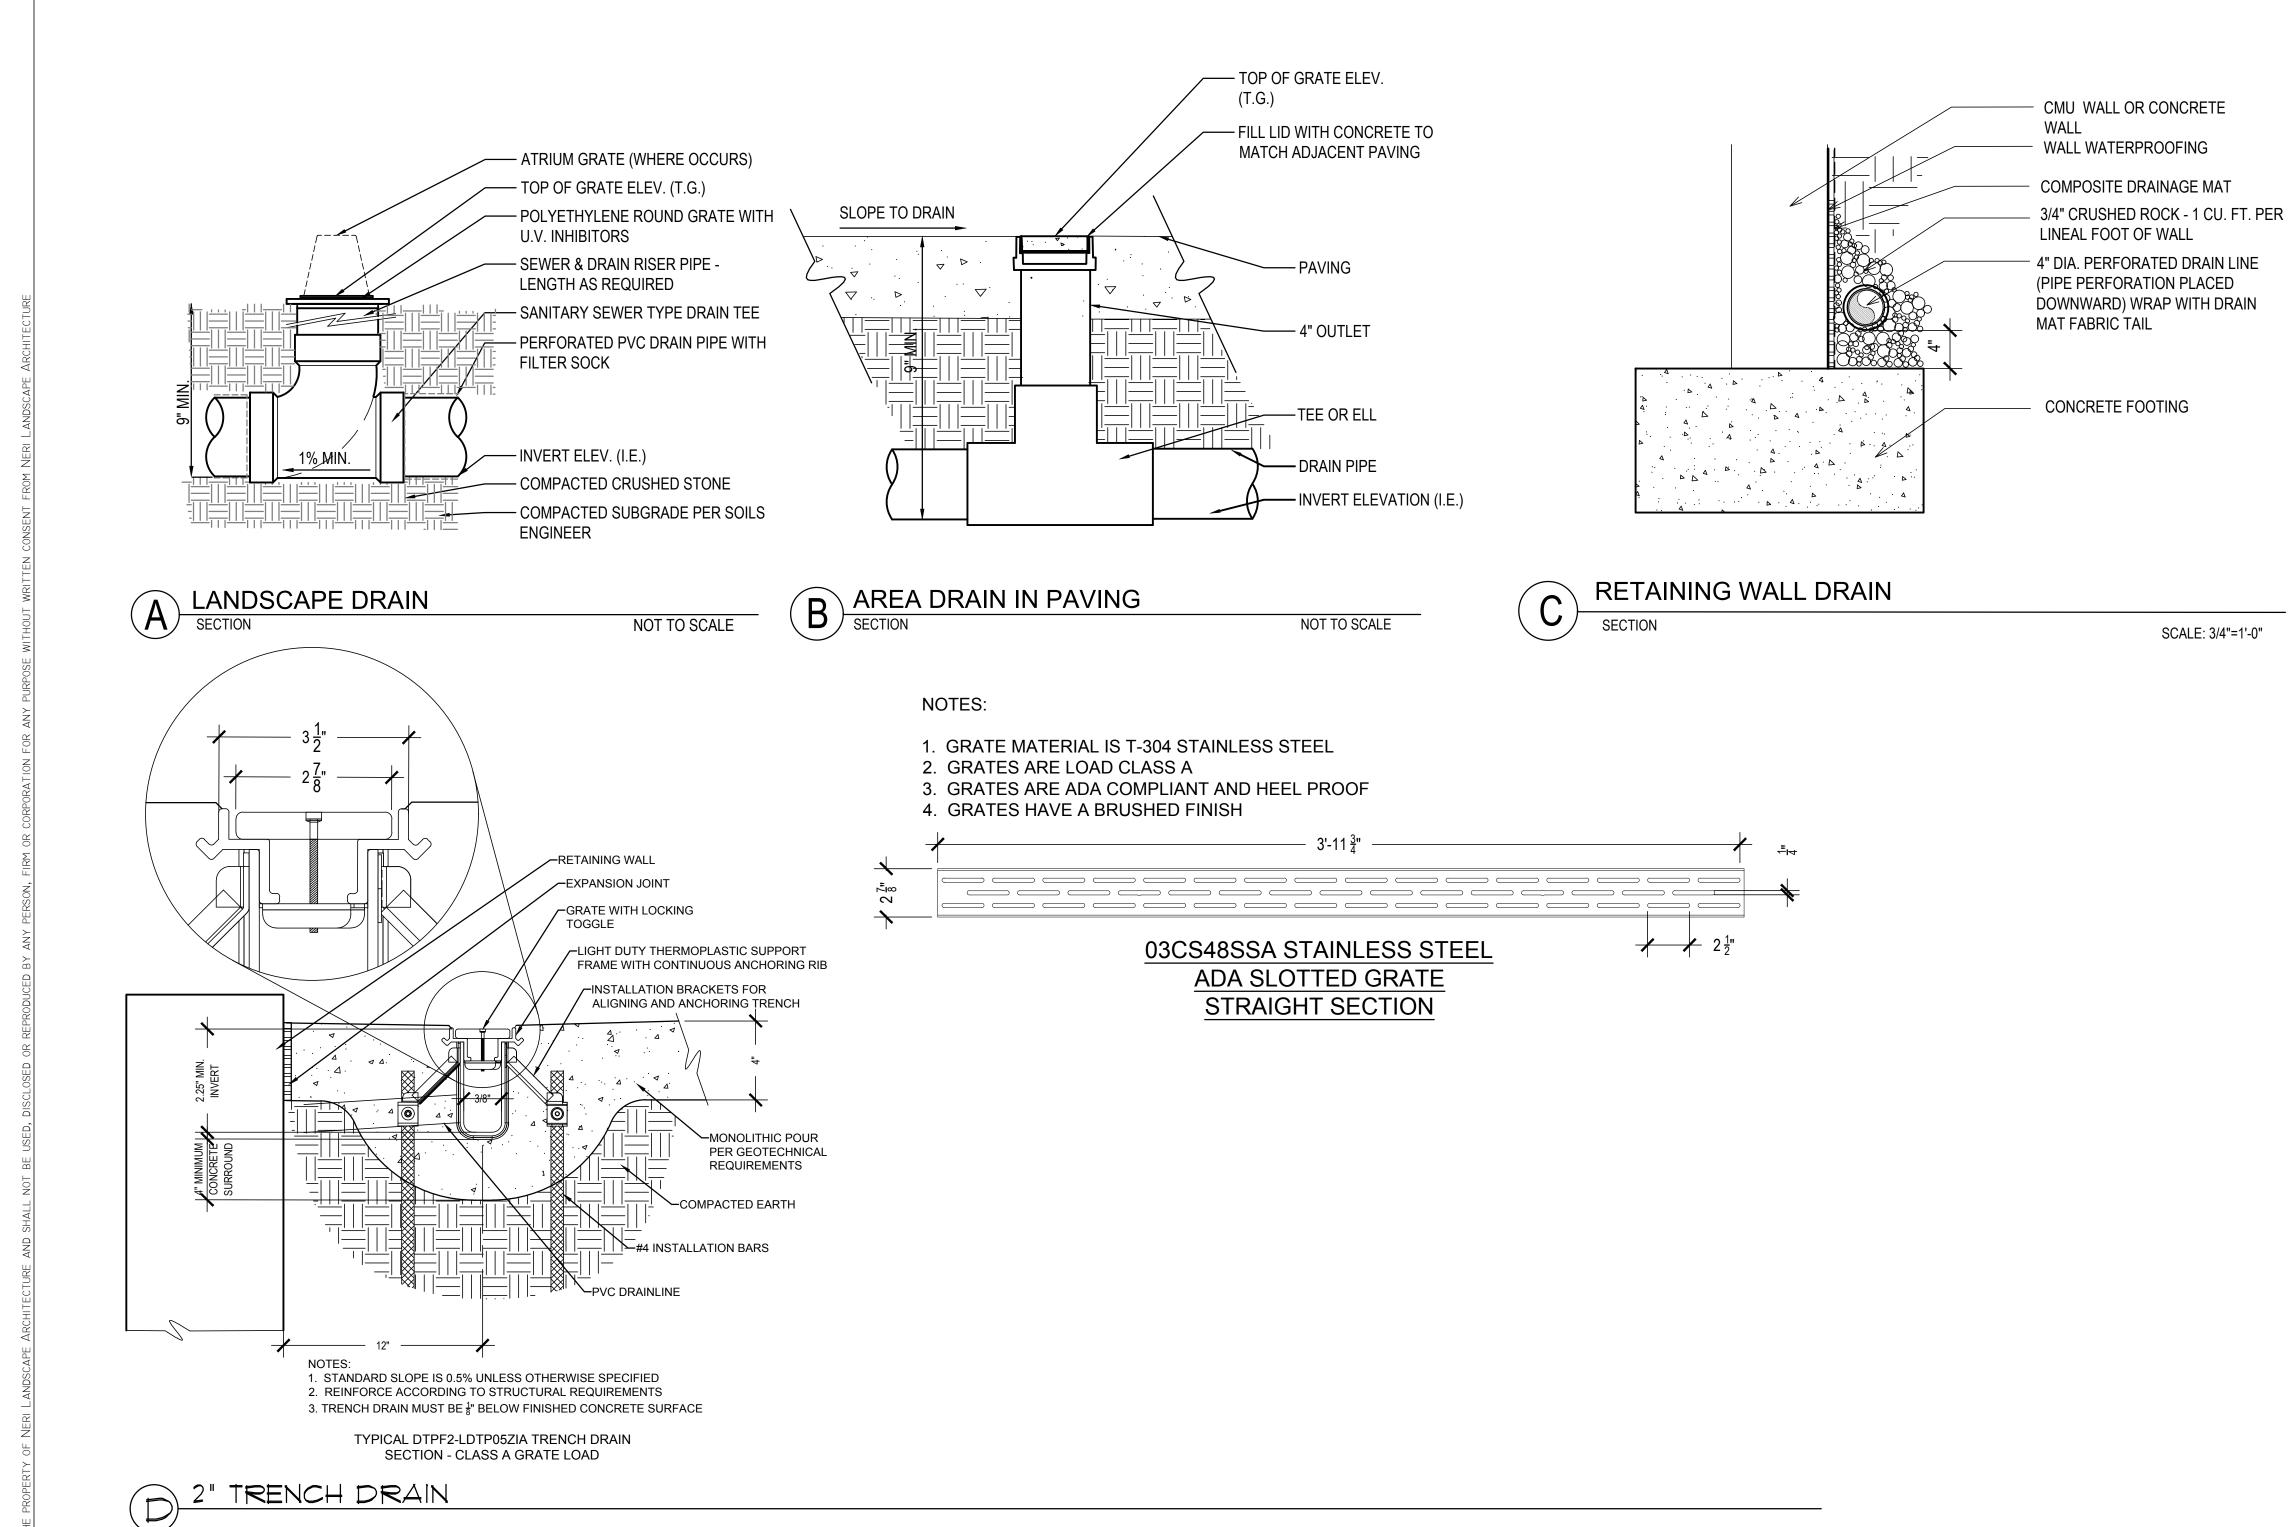

70. -NG. -DA

PE CT C PE Ch

NERI LANDSCAPE ARCHITECTUR

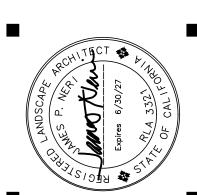

SIGN PLAN FOR

WHOTEL

quier Road

MACKINAW F
3001 Jacquier Rog

CITY SUBMITTAL

9/18/2025

LANDSCAPE DRAINAGE

L0.2

1.01 SUMMARY

- A. Prepare and Submit Spa Shop Drawings for Architect Approval. Submit approved Spa Shop Drawings to El Dorado County for review and approval.
- B. Provide and install pump, filters, sanitizers, autofills, controls, electrical connections, drains, and the necessary hydraulics to construct a functioning, clean, re-circulating water system.
- C. Spa: Chlorinated saltwater system

1.02 SYSTEM DESCRIPTION

- A. Design Requirements:
- 1. Electrical: Provide/install a waterproof on/off switch adjacent to the spa. Provide an electrical junction box mounted on the equipment wall. Provide electrical connections to all powered spa equipment.
- 1. Pumps: Provide for booster pump, acid pump
- 1. Filter/backwash: Provide for spa a sand filter sized to allow for continuous daily operation and requiring maximum weekly inspection.
- 2. Sanitizer: Provide water sanitizing for continuous automatic slipstream application of biocide to maintain the equivalent of 5 ppm chlorine.
- 3. Autofill: Provide a combination hydraulic overflow and autofill
- 4. Controls: Provide automatic shut-off in the event of pump failure. Provide Control System for Spa
- 5. Spa Heater: Provide a 240V electric spa heater
- 6. Electrical Connections: Provide the services of a licensed electrician to make all electrical connections according to local code and standard practice.
- 7. Plumbing: Provide unimpeded, consistent flow of clear, clean water through orifices. Provide fittings for convenient cleaning of pipe. Size and valve water delivery equipment to allow for increasing or decreasing flow adjustment.
- 8. Signage: Provide and install all safety, regulation and warning signage required by permitting agencies.
- 9. Lighting: (2) spa lights

SPA MATERIALS LEGEND - DEFERRED SUBMITTAL & PERMITTING REQUIRED BY POOL CONTRACTOR

PLAN SYMBOL &	DESCRIPTION	SOURCE	MATERIAL / FINISH / NOTES	DETAIL
spa depth markers — spa coping — spa steps with non-sl tile nosing contrasting edge color skimmer — stainless steel handra gunited pool shell spa lift spa bench	SPA	STAIR NOSING TILE: DAL TILE (858) 571-1957	POOL SHELL: SHOTCRETE CONCRETE STRUCTURE WITH POOL PLASTER COLOR: WHITE POOL STEPS NOSING TILE: 2" X 2" NON SLIP TILE ONE ROW HORIZONTAL AND ONE ROW VERTICAL AT EACH STAIR NOSING 'MATTE EBONY UP22' NON-SLIP CERAMIC TILE BY 'DAL TILE' WATERLINE TILE: 2" X 2" NON SLIP TILE THREE ROWS HORIZONTAL 'MATTE EBONY UP22' NON-SLIP CERAMIC TILE BY 'DAL TILE' WATERLINE TILE COLOR SHALL BE CONTRASTING IN COLOR TO THE POOL WHITE PLASTER	
	ADA PERMANENT POOL/ SPA LIFT	ICA, INTER-FAB INCORPORATED (520) 790.7040	SWIM ASSIST EXCEL LR #ICA-SAE-LR-300-42-GY	C/L1.6
coping —	SPA COPING	QUICK CRETE (866) 703-3434	'CATALINA' CUSTOM PRECAST CONCRETE COPING WITH SLIP RESISTANT 'ECCOSTONE' TEXTURE AND REMOVABLE SECTIONS. COLOR: 'NATURAL' WITH STANDARD MATT SEALER	E/L1.6
+ + + + + + + + + + + +	E.J. CONCRETE PAVING POOL & SPA SLIP RESISTANT DECK PAVING	LOCAL BATCH PLANT	CONCRETE FINISH: TOPCAST #5 SEALER: CONSOLIDECK 'SALTGUARD'	A,B/L1.3

EQUIPMENT	MANUFACTURER	MODEL	DESCRIPTION	QTY.
PUMP	PENTAIR	WFE-8	2HP HIGH PERFORMANCE PUMP @ MAX. 113 GPM (#011515)	1
BOOSTER PUMP	PENTAIR	WFE-8	2HP HIGH PERFORMANCE PUMP @ MAX. 113 GPM (#011515)	1
FILTER	PENTAIR	TR-140C	HIGH CAPACITY FIBERGLAS SAND FILTER @ 141 GPM	1
HEATER	JANDY	HI-E2 EHE350NS	350K BTUH DIGITAL ASME HEATERS (HI-E2)	1
FLOWMETER	BLUE & WHITE	F-300	F-30250P (2-1/2")	1
CHEMICAL CONTROLLER	ROLA-CHEM	554308	DISINFECTANT DIGITAL CONTROLLER (PH/ORP)	1
CHLORINATOR	ROLA-CHEM	RC 25/53SC	LIQUID CHLORINE PUMP (MAX. 12 LBS/DAY)	1
ACID PUMP	ROLA-CHEM	RC 25/53SC	LIQUID ACID PUMP (MAX. 12 LBS/DAY)	1
LIGHT	PENTAIR	AMERLITE	300 WATT UNDERWATER WHITE LIGHT	1
SKIMMER	WATERWAY	540-6200	COMMERCIAL RENEGADE GUNITE IN -GROUND SKIMMER	2
EQUALIZER COVER	AQUASTAR	6HP1010	6" ROUND HOCKEY PUCK SUMPLESS SUCTION OUTLET COVER	4
MAIN DRAIN	AFRAS	ABF-64A	11-1/8" ROUND DRAIN COVERS	2
BOOSTER MAIN DRAIN	AFRAS	ABF-64A	11-1/8" ROUND DRAIN COVERS	2
WALL RETURN	WATERWAY	400-9190	FLUSH MOUNT RETURN FITTING (WHITE COLOR)	2
JET RETURN	WATERWAY	210-3330	10" TEE-1-1/2" Sx ¹ / ₂ " S-3/4" SPIGOT x ¹ / ₂ " SPIGOT	8
CHLORINE TANK	CARBOYS	50 GALLON	50 GAL STORAGE DRUM	1
ACID TANK	CHEMTAINER	35 GALLON	35 GAL DOUBLE WAL STORAGE TANK	1
ACID FUME SCRUBBER	PROMINENT	7747090		1
WATER LEVELER	LEVOLOR	K1100	AUTOMATIC WATER LEVELER SYSTEM	1
CONTROLLER	PENTAIR	LX802	COMMERCIAL SPA CONTROL SYSTEM	1
SALT SYSTEM	PENTAIR	COMSYS-2	SALT GENERATION SYSTEM	1


- 1. EQUIPMENT SHOWN FOR REFERENCE ONLY SUBMIT EQUIPMENT LIST EQUIVALENT TO COMPONENTS SHOWN AND ACCORDING TO TITLE 22 & 24 AND LOCAL MUNICIPAL & HEALTH CODES
- 2. MOUNT PRESSURE GAUGES AT SAME HEIGHT
- 3. PIPE SHALL BE SHEDULE 40 PVC, FITTINGS SHALL BE SCHEDULE 80 PVC
- 4. TAG VALVES WITH WATERPROOF OPERATING CARDS
- STORE HAZARDOUS MATERIALS PER CBC TABLES 307.1 (1) AND 307.2 (2)
- 6. INSTALL EQUIPMENT PER MANUFACTURER'S REQUIREMENTS
- PROVIDE LEGAL AIR GAP AND SIGHT GLASS AT FILTER BACKWASH TO SANITARY SEWER
- 8. INSTALL FLOW METER 10X PIPE DIAMETER FROM UPSTREAM CONNECTION AND WITH 4X PIPE DIAMETER DOWNSTREAM FROM METER
- 9. AUTO TEMPERATURE CONTROL AND INTERNAL BY-PASS REQUIRED FOR HEATER

MATERIAL SCHEDULE

SYMBOL	DESCRIPTION	SOURCE	MATERIAL/ FINISH/NOTES	DETAIL
E.J. SAW CUT	PAVING TYPE 'A' PEDESTRIAN, 4" THK. CONCRETE WITH ENHANCED FINISH & GLOSS SEALER	LOCAL BATCH PLANT	COLOR: UNCOLORED FINISH: TOPCAST 05, SANDBLAST SEALER: GLAZE 'N SEAL GREEN	A, B/ L1.2
'B'	PAVING TYPE 'B' VEHICULAR CONCRETE PAVING - SEE CIVIL PLANS	LOCAL BATCH PLANT	COLOR: UNCOLORED FINISH: TOPCAST 05, SANDBLAST SEALER: GLAZE 'N SEAL GREEN	CIVIL PLANS
0°	LANDSCAPE BOULDER	SALVAGED EXISTING SITE BOULDERS	BOULDER SIZE VARIES FROM 1'-5' - 3' SIZE, SELECT ELONGATED BOULDERS AND BURY BOTTOM HALF PER DETAIL	B/ L1.6
	FITNESS EQUIPMENT	ROGUE FITNESS WWW.ROUGEFITNESS.COM	MODEL: MONSTER RIG 2.0 INSTALL PER MANUFACTURER'S REQUIREMENTS - DEFERRED SUBMITTAL REQUIRED BY INSTALLING CONTRACTOR	C/ L1.6
	BIKE RACK	CONTRACTOR FABRICATED	'STAMP MILL' STEEL TUBES	E/ L1.3
	WOOD BENCH	CONTRACTOR FABRICATED	CMU WALL SIZE: 8"x8"x16" CMU FINISH: STUCCO COLOR: TBD, BENCH WOOD: CEDAR FINISH: SAND & APPLY PENETRATING OIL FINISH	D,G/ L1.5
	FIRE BOWL WITH ELECTRIC START AND TIMER	KINDRED OUTDOORS + SURROUNDS WWW.MYKINDREDLIVING.COM	STYLE: TUYA COLOR: AGED TEAK HONED FINISH: HONED STONES: TUMBLED LAVA ROCK, DARK GRAY	F/ L1.5
GATE 2 FENCE	TUBULAR STEEL FENCE AT SPA	CONTRACTOR FABRICATED	MIN. 5' HIGH TUBULAR STEEL FENCE	A/ L1.5
GATE 1	PATIO SECURITY 6' TUBULAR STEEL FENCE	CONTRACTOR FABRICATED	6' HIGH TUBULAR STEEL FENCE	C/ L1.5
GLASS GUARDRAIL RETAINING WALL	PATIO 5' HIGH, GLASS GUARDRAIL , PAVING MOUNTED	'CR LAURENCE' www.crlaurence.com	MODEL: FSC FRAMELESS 1/2" TEMPERED GLASS WITH AFWC1 ONE-PIECE CORE MOUNT FRAMELESS WINDSCREEN CLAMP.	A/L1.6
	DETECTABLE WARNING - TRUNCATED DOMES			SEE CIVIL PLANS


GATE SCHEDULE


SYMBOL	DESCRIPTION	SIZE	MATERIAL	OPERATION	DETAIL
GATE 1	PEDESTRIAN ACCESS GATE SWING GATE	3'-0" W x 6'H	TUBULAR STEEL GATE	MANUAL WITH KEYED LOCKSET, PANIC HARDWARE & CARD READER	C/ L1.5
GATE 2	SPA ENCLOSURE SWING GATE	3'-0" W x 6'H	TUBULAR STEEL GATE	MANUAL WITH KEYED LOCKSET, PANIC HARDWARE & CARD READER	B/ L1.5

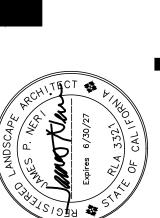

CKINAW

CITY SUBMITTAL

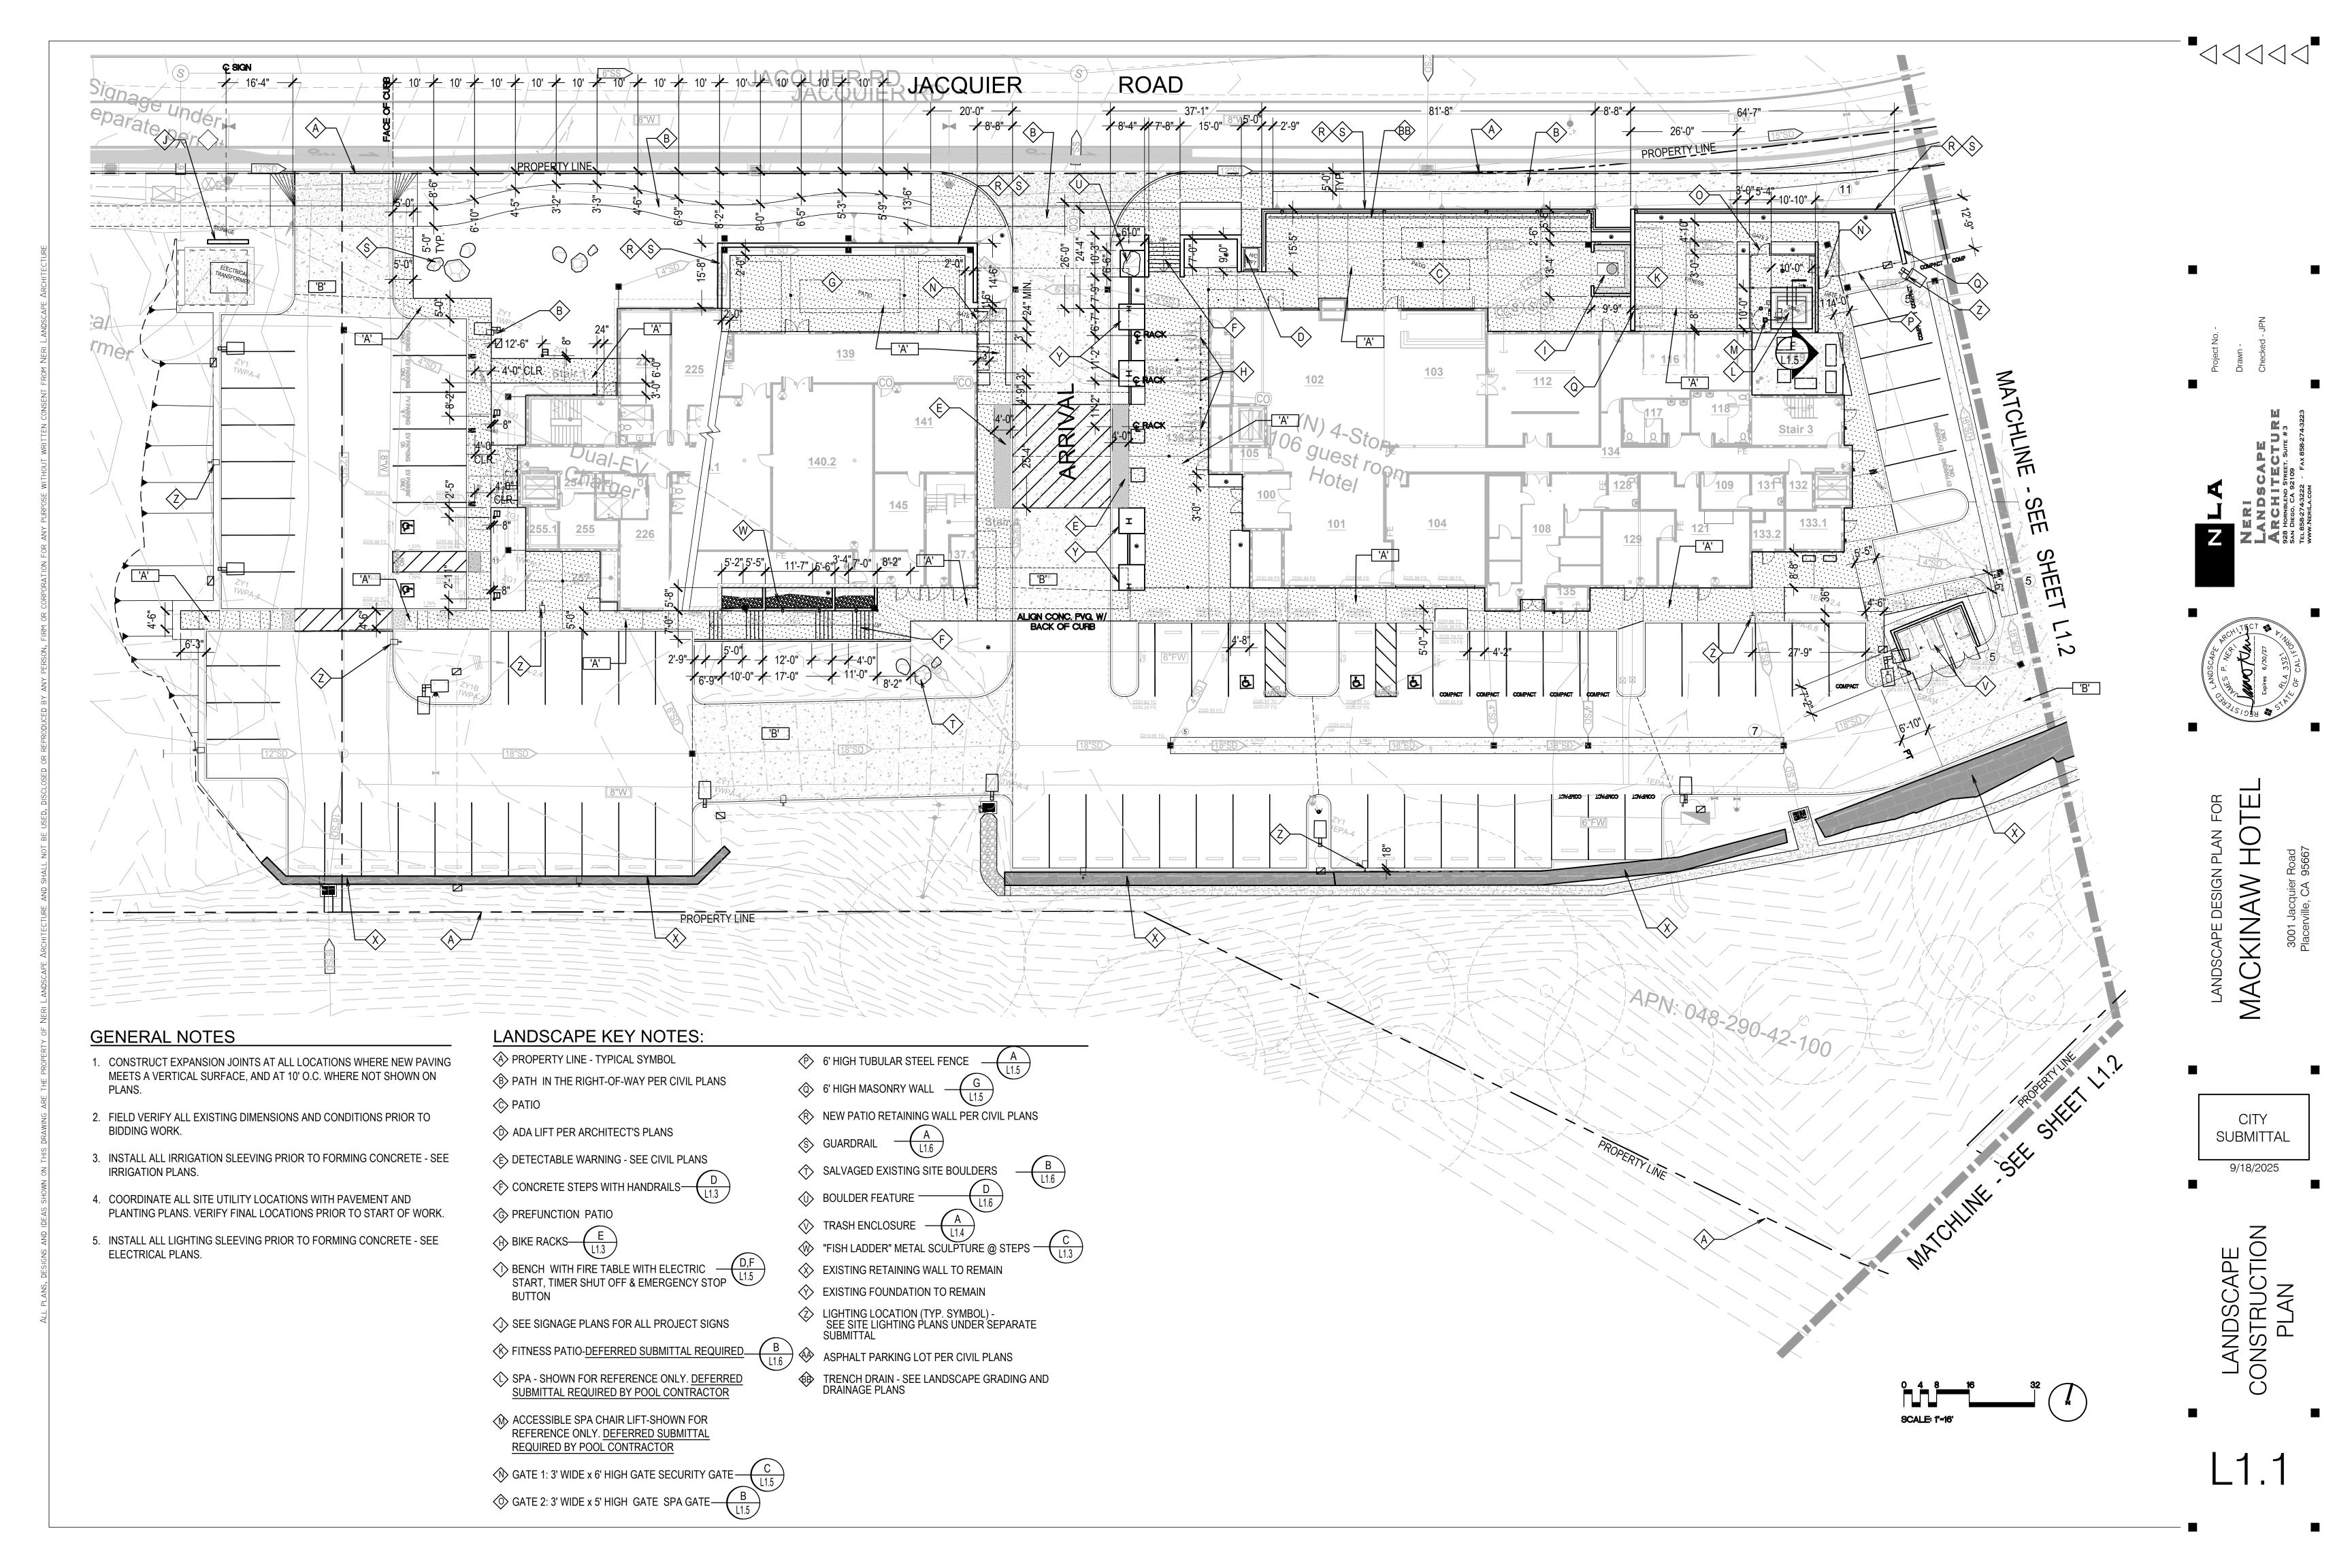

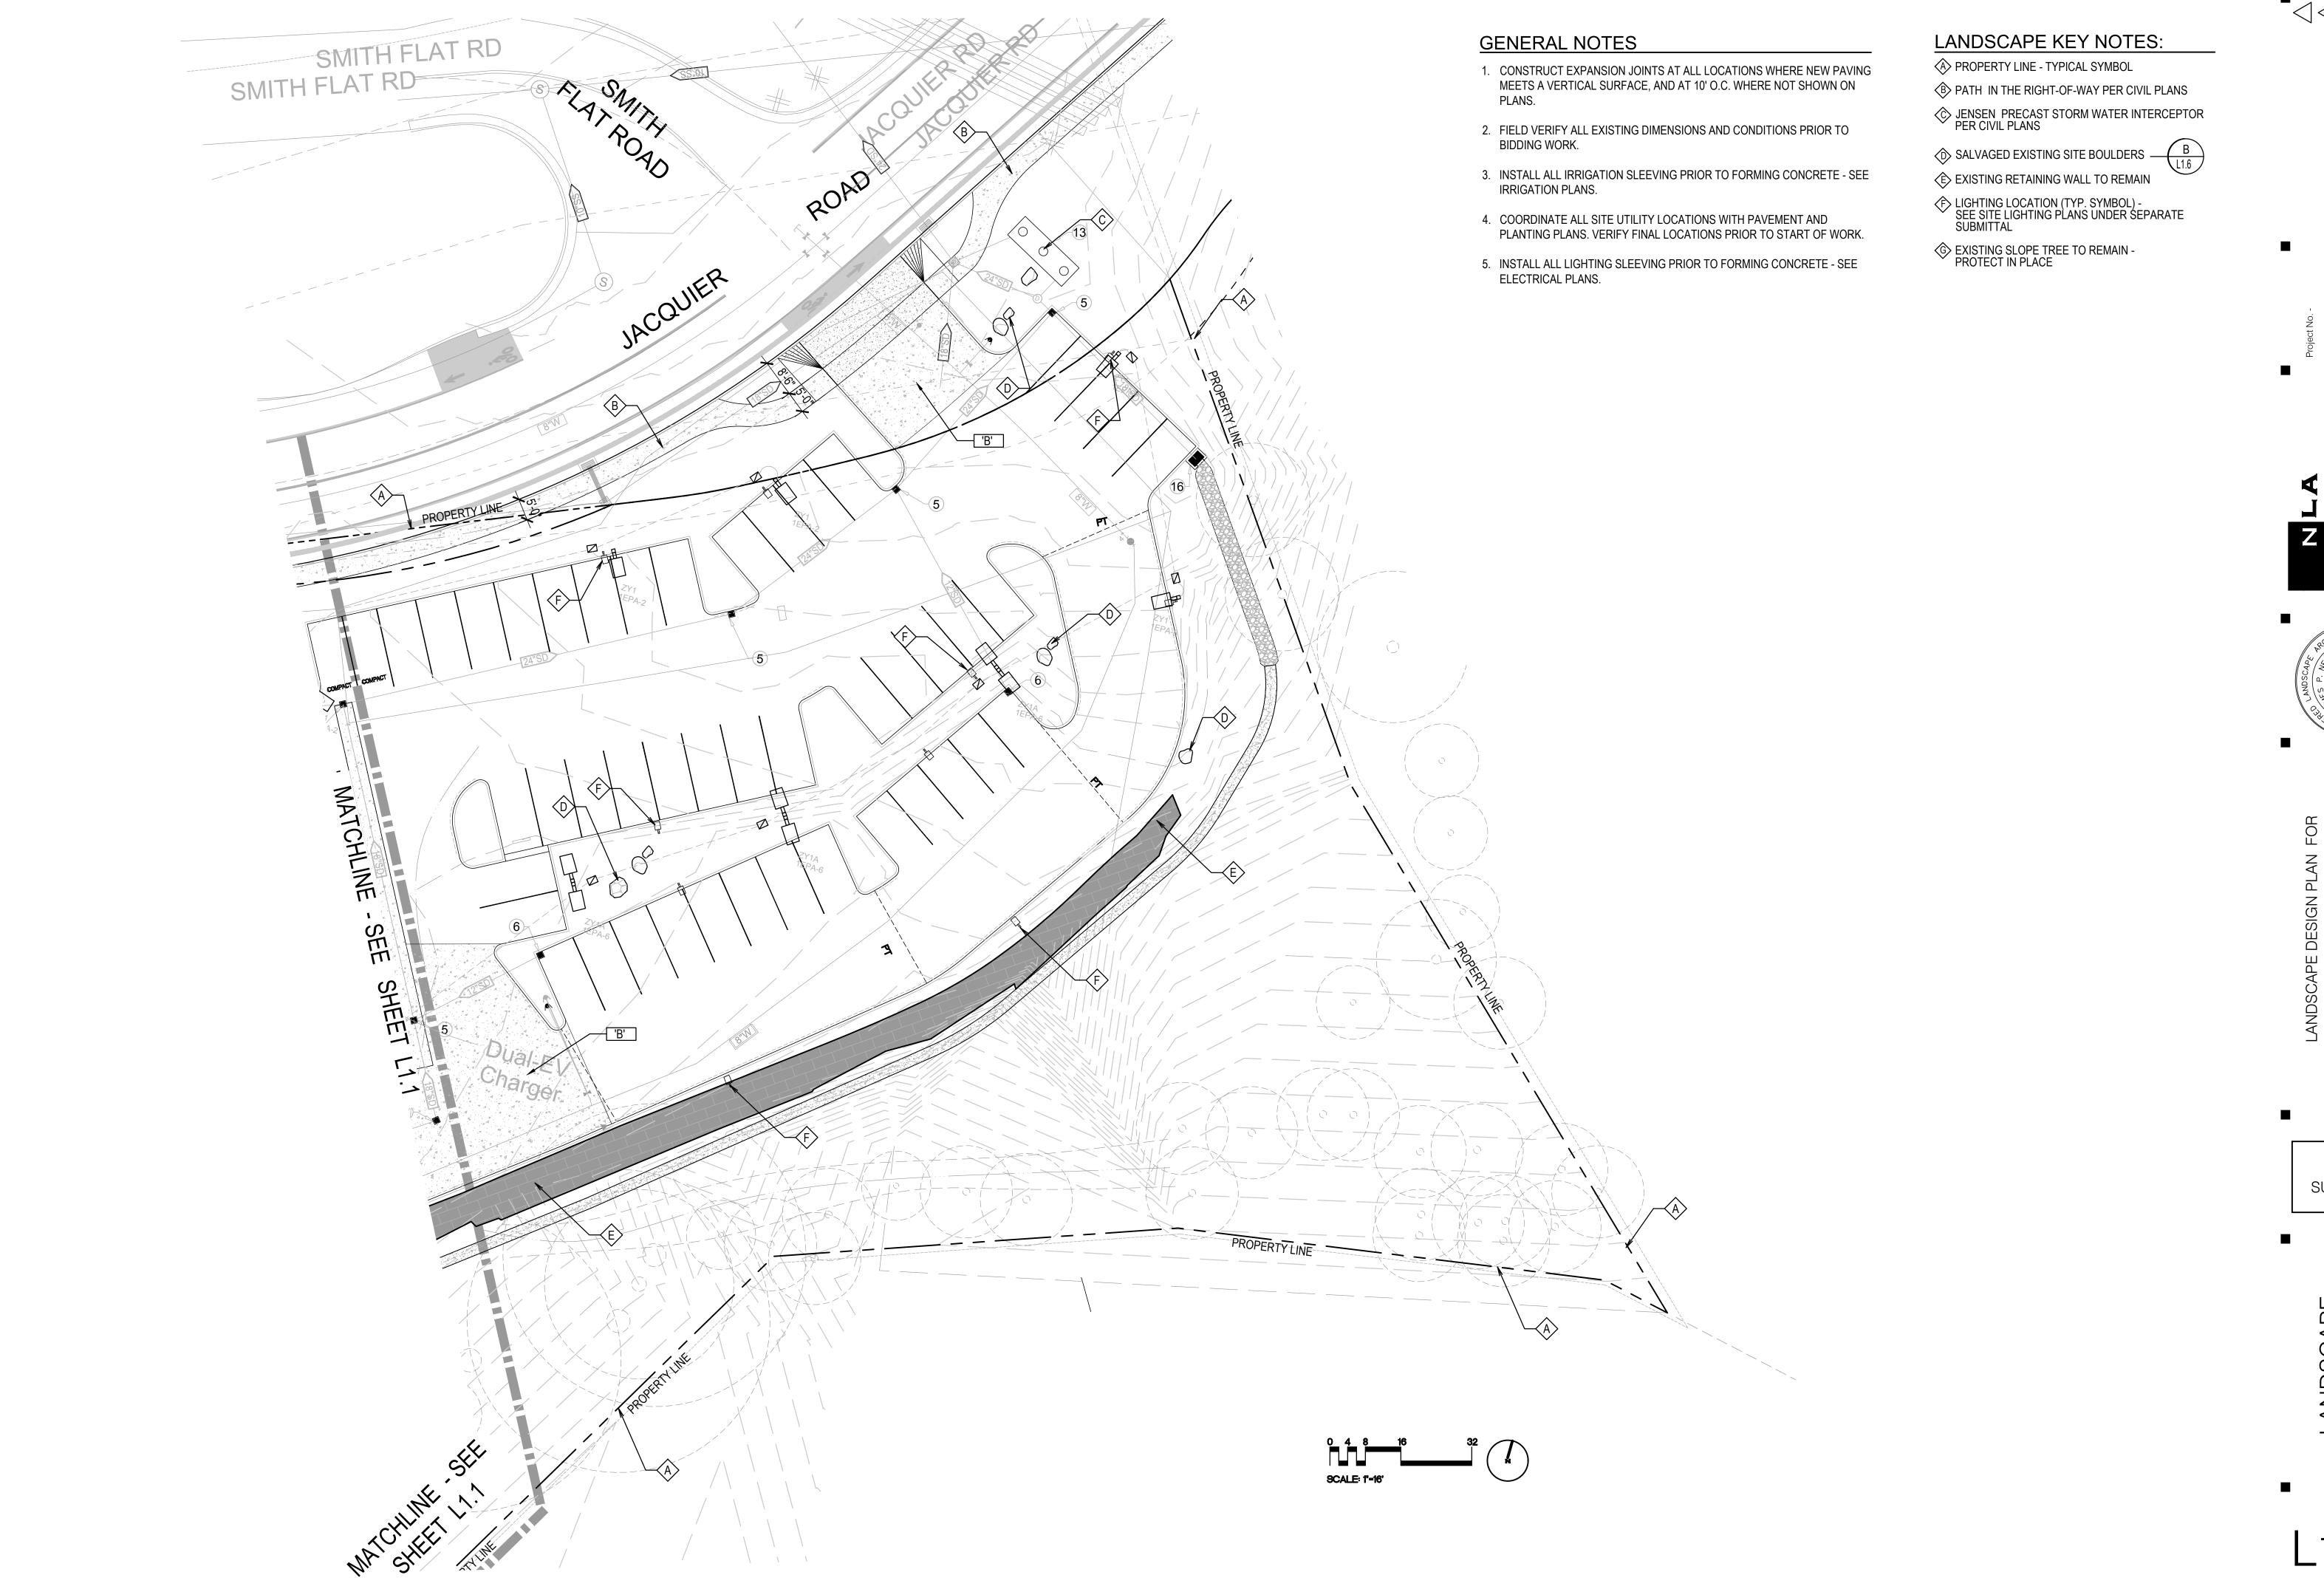

Project No. -Drawn -Checked - JPN

> ERI NDSCAPE RCHITECTURE ORNBLEND STREET, SUITE #3

Expires 6/30/27

Expires 6/30/27

Expires 6/30/27

Expires 6/30/27


MACKINAW HOTEL
3001 Jacquier Road


CITY SUBMITTAL


9/18/2025


LANDSCAPE CONSTRUCTION PLAN


L1.2

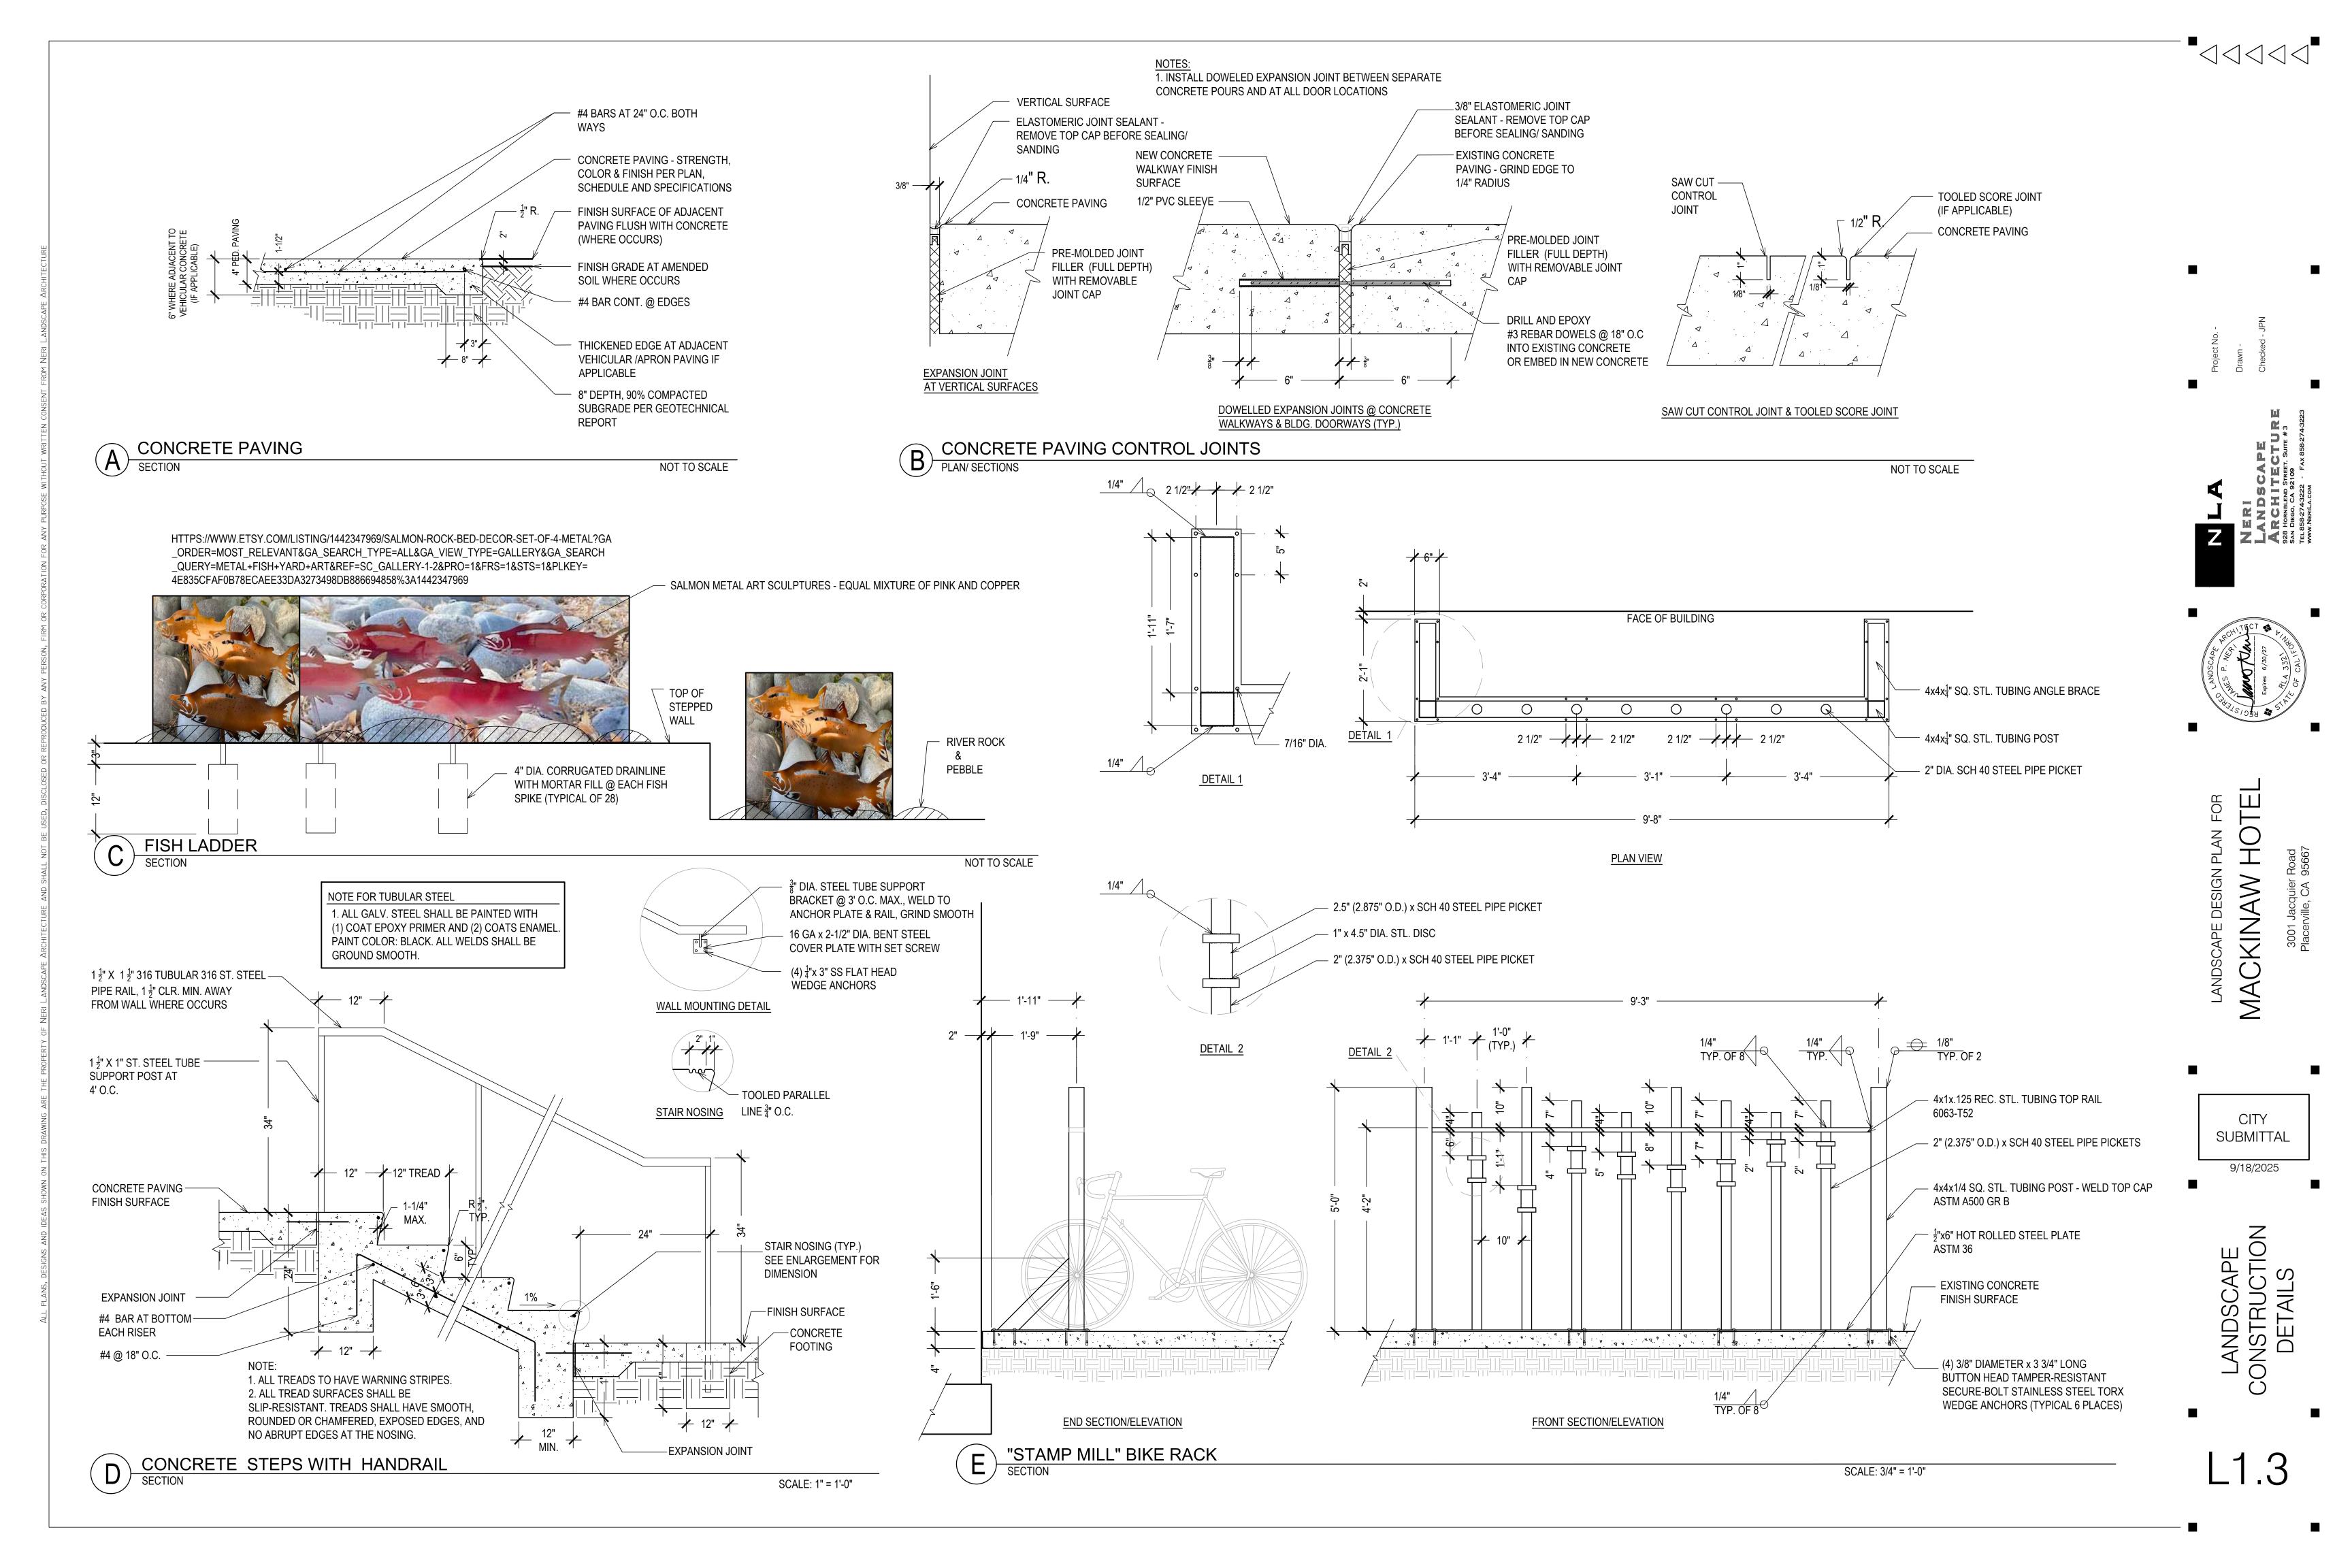


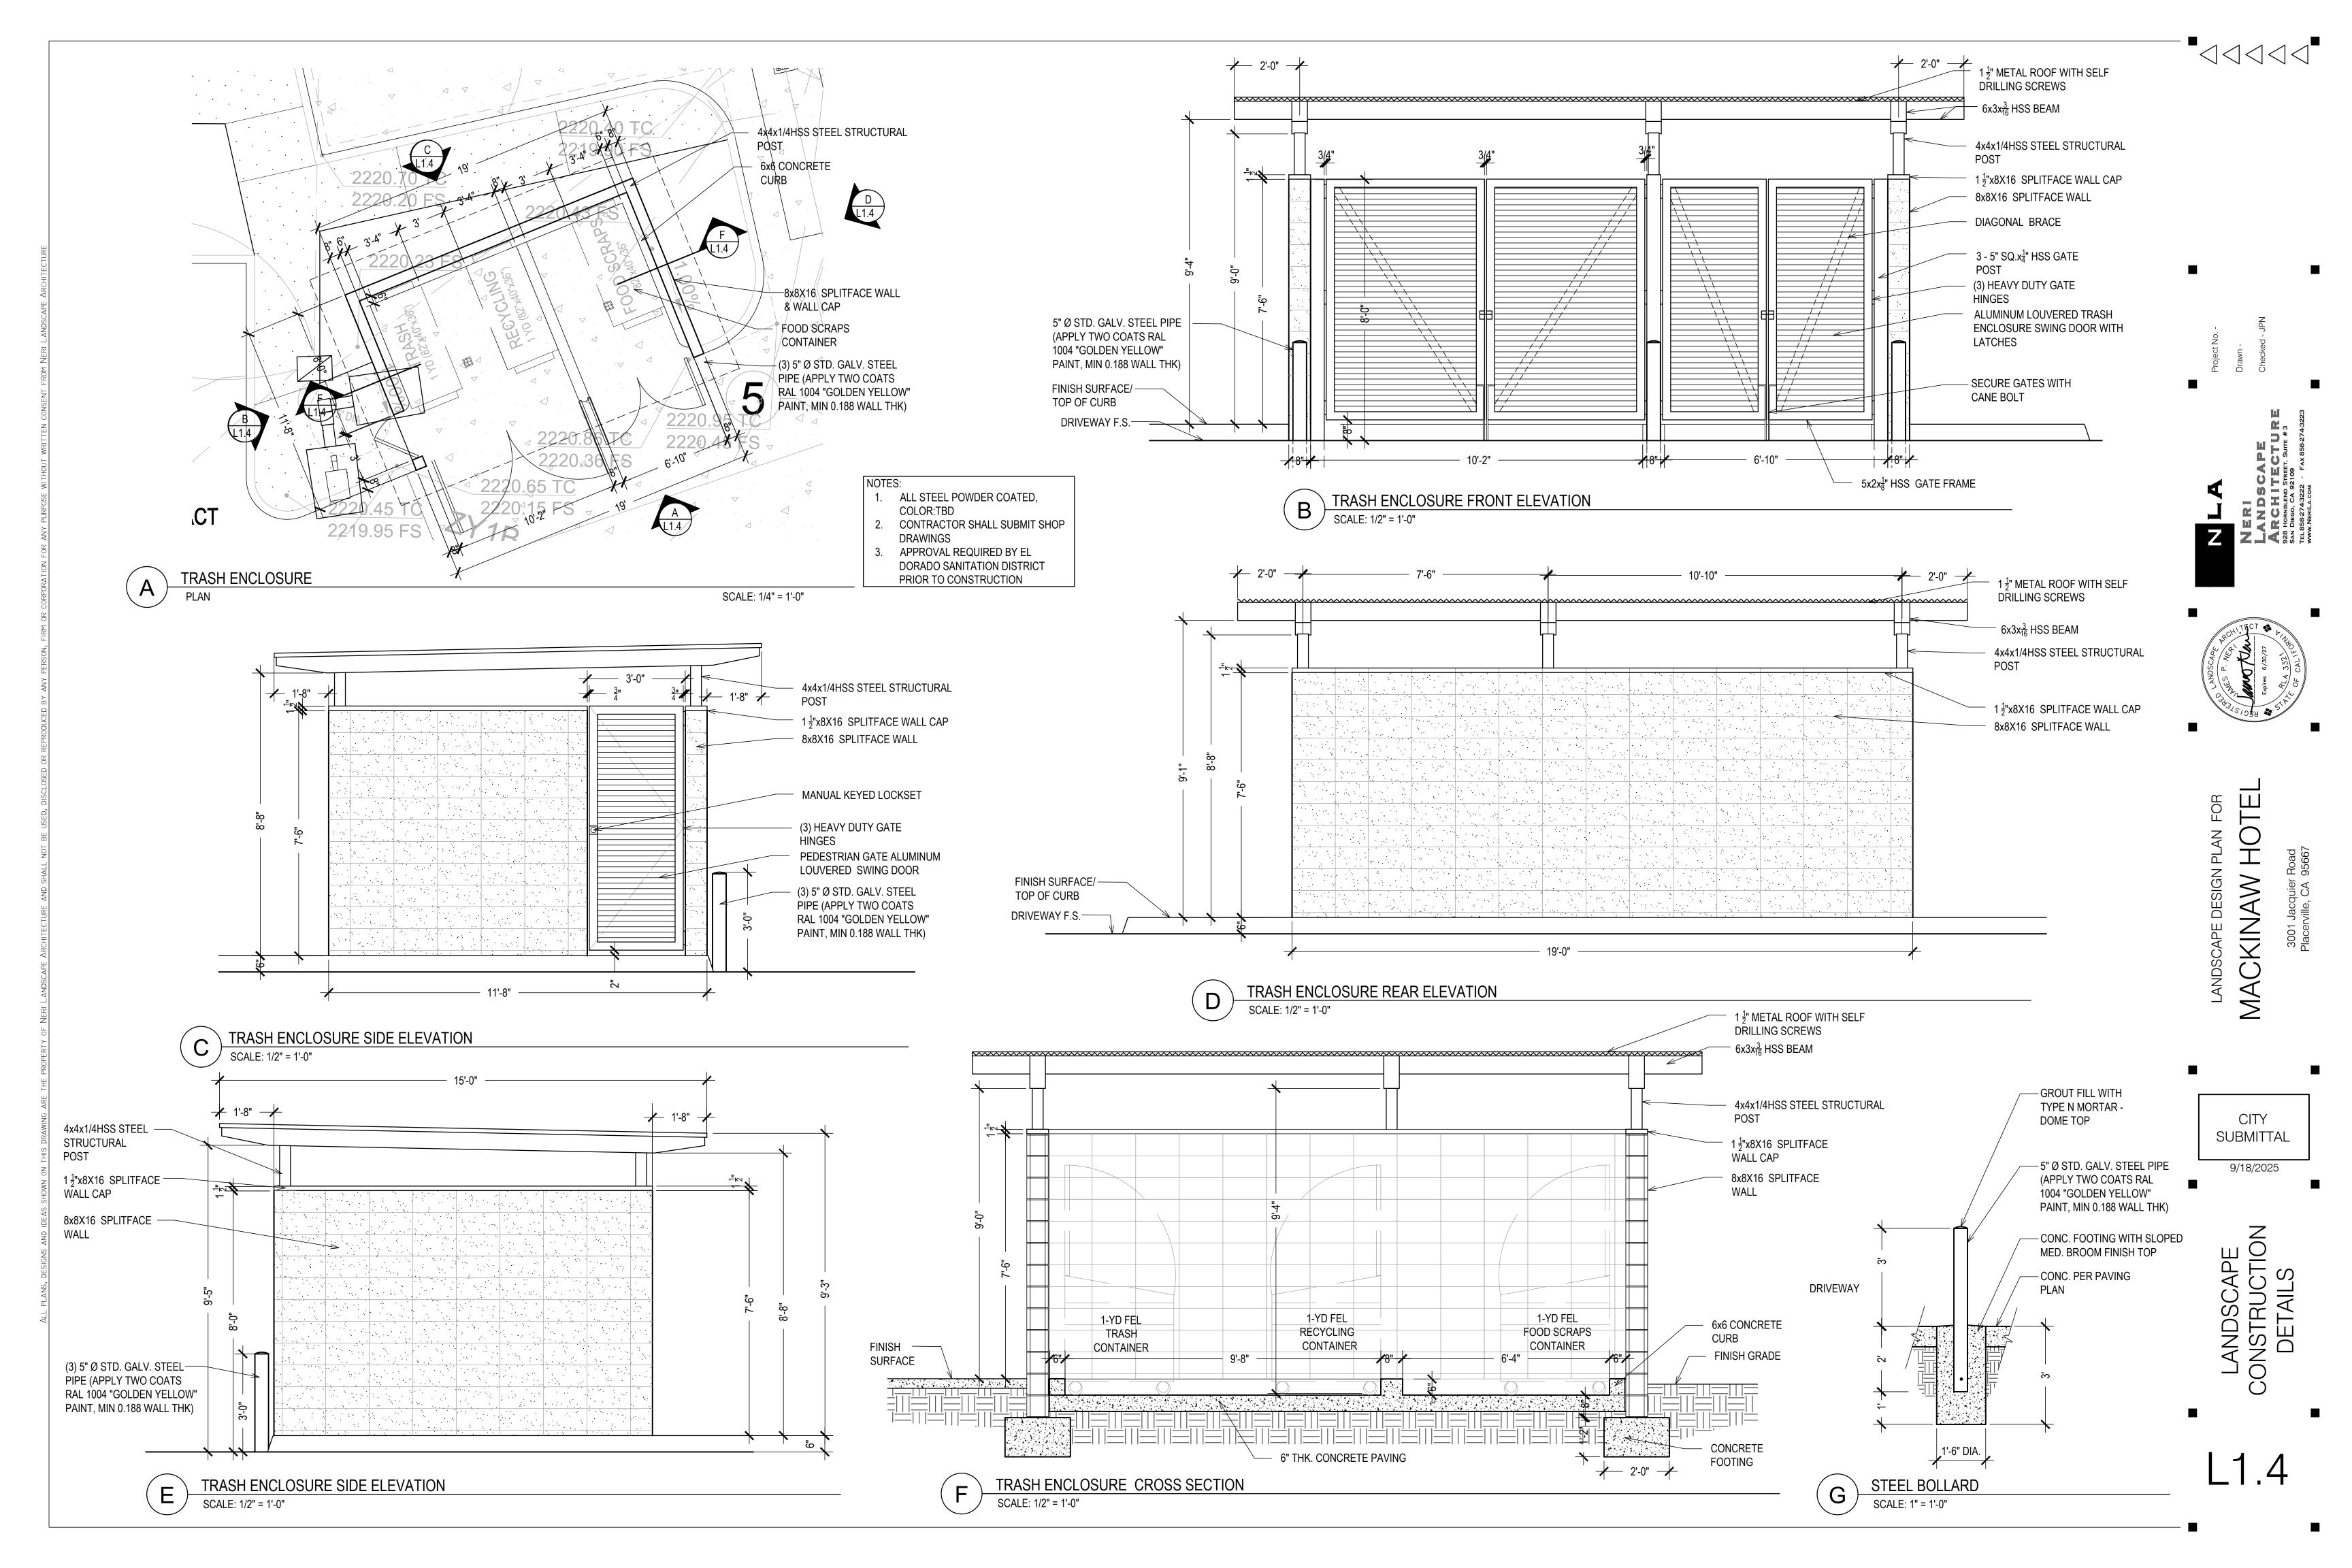

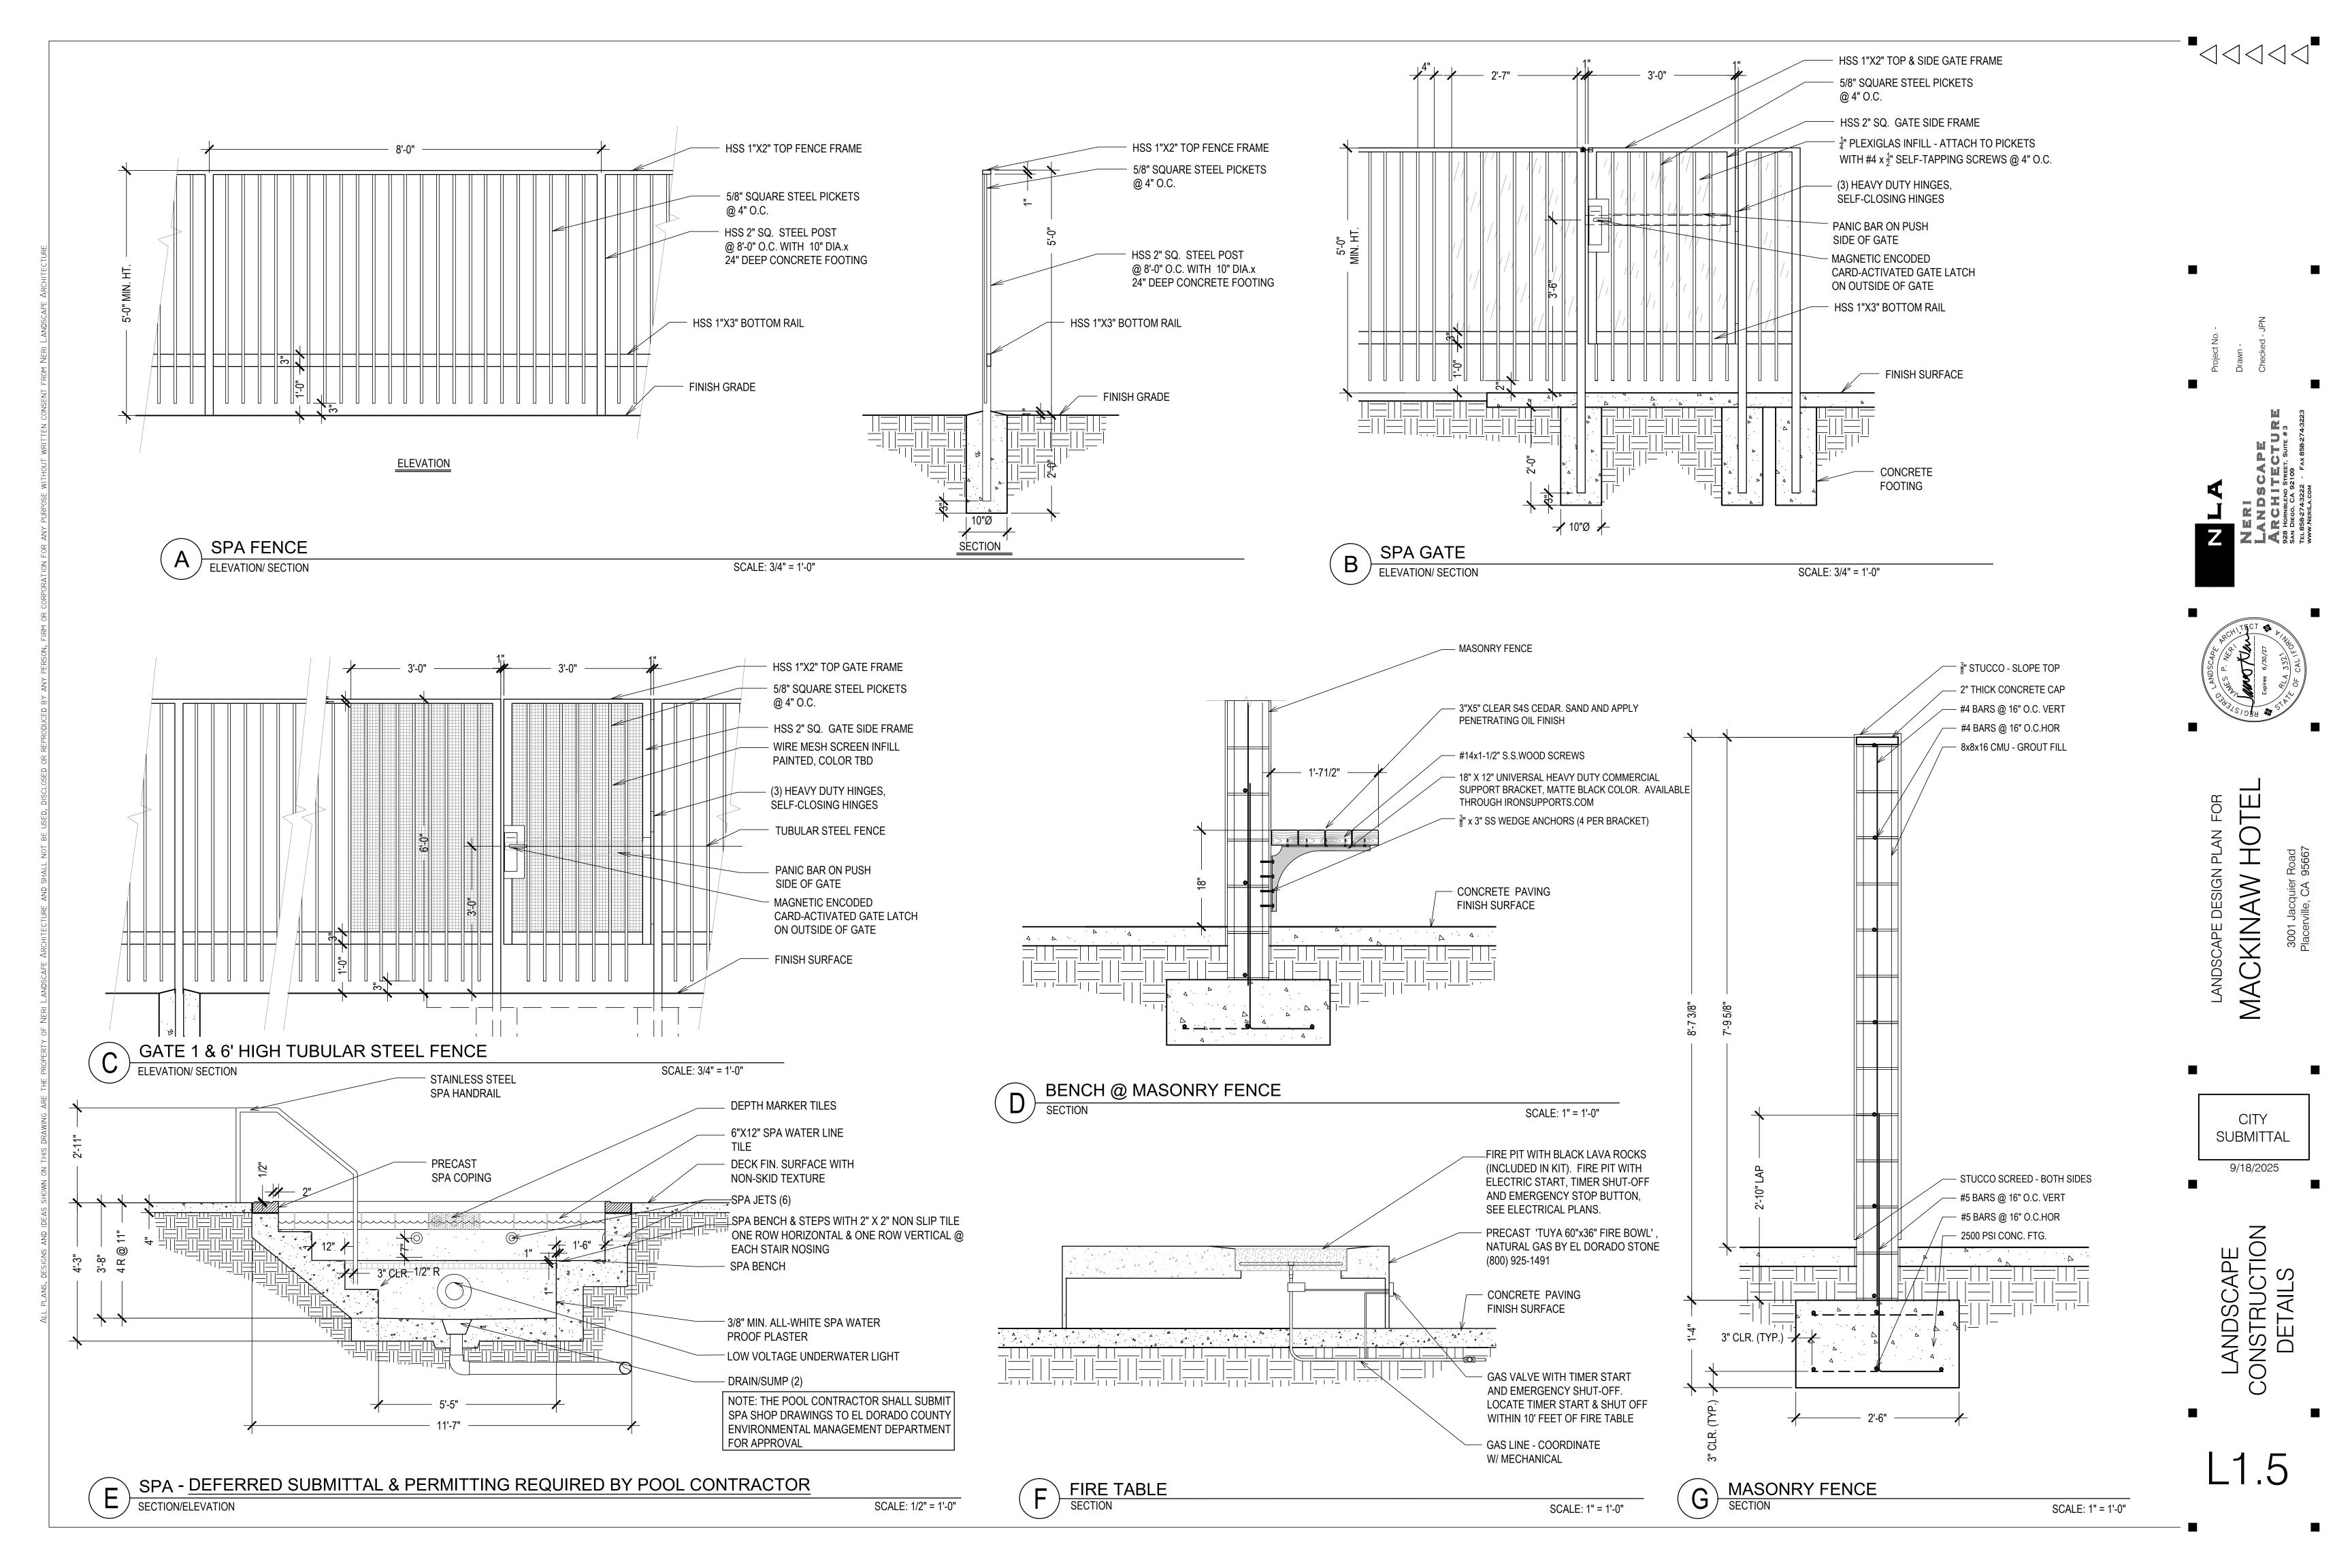

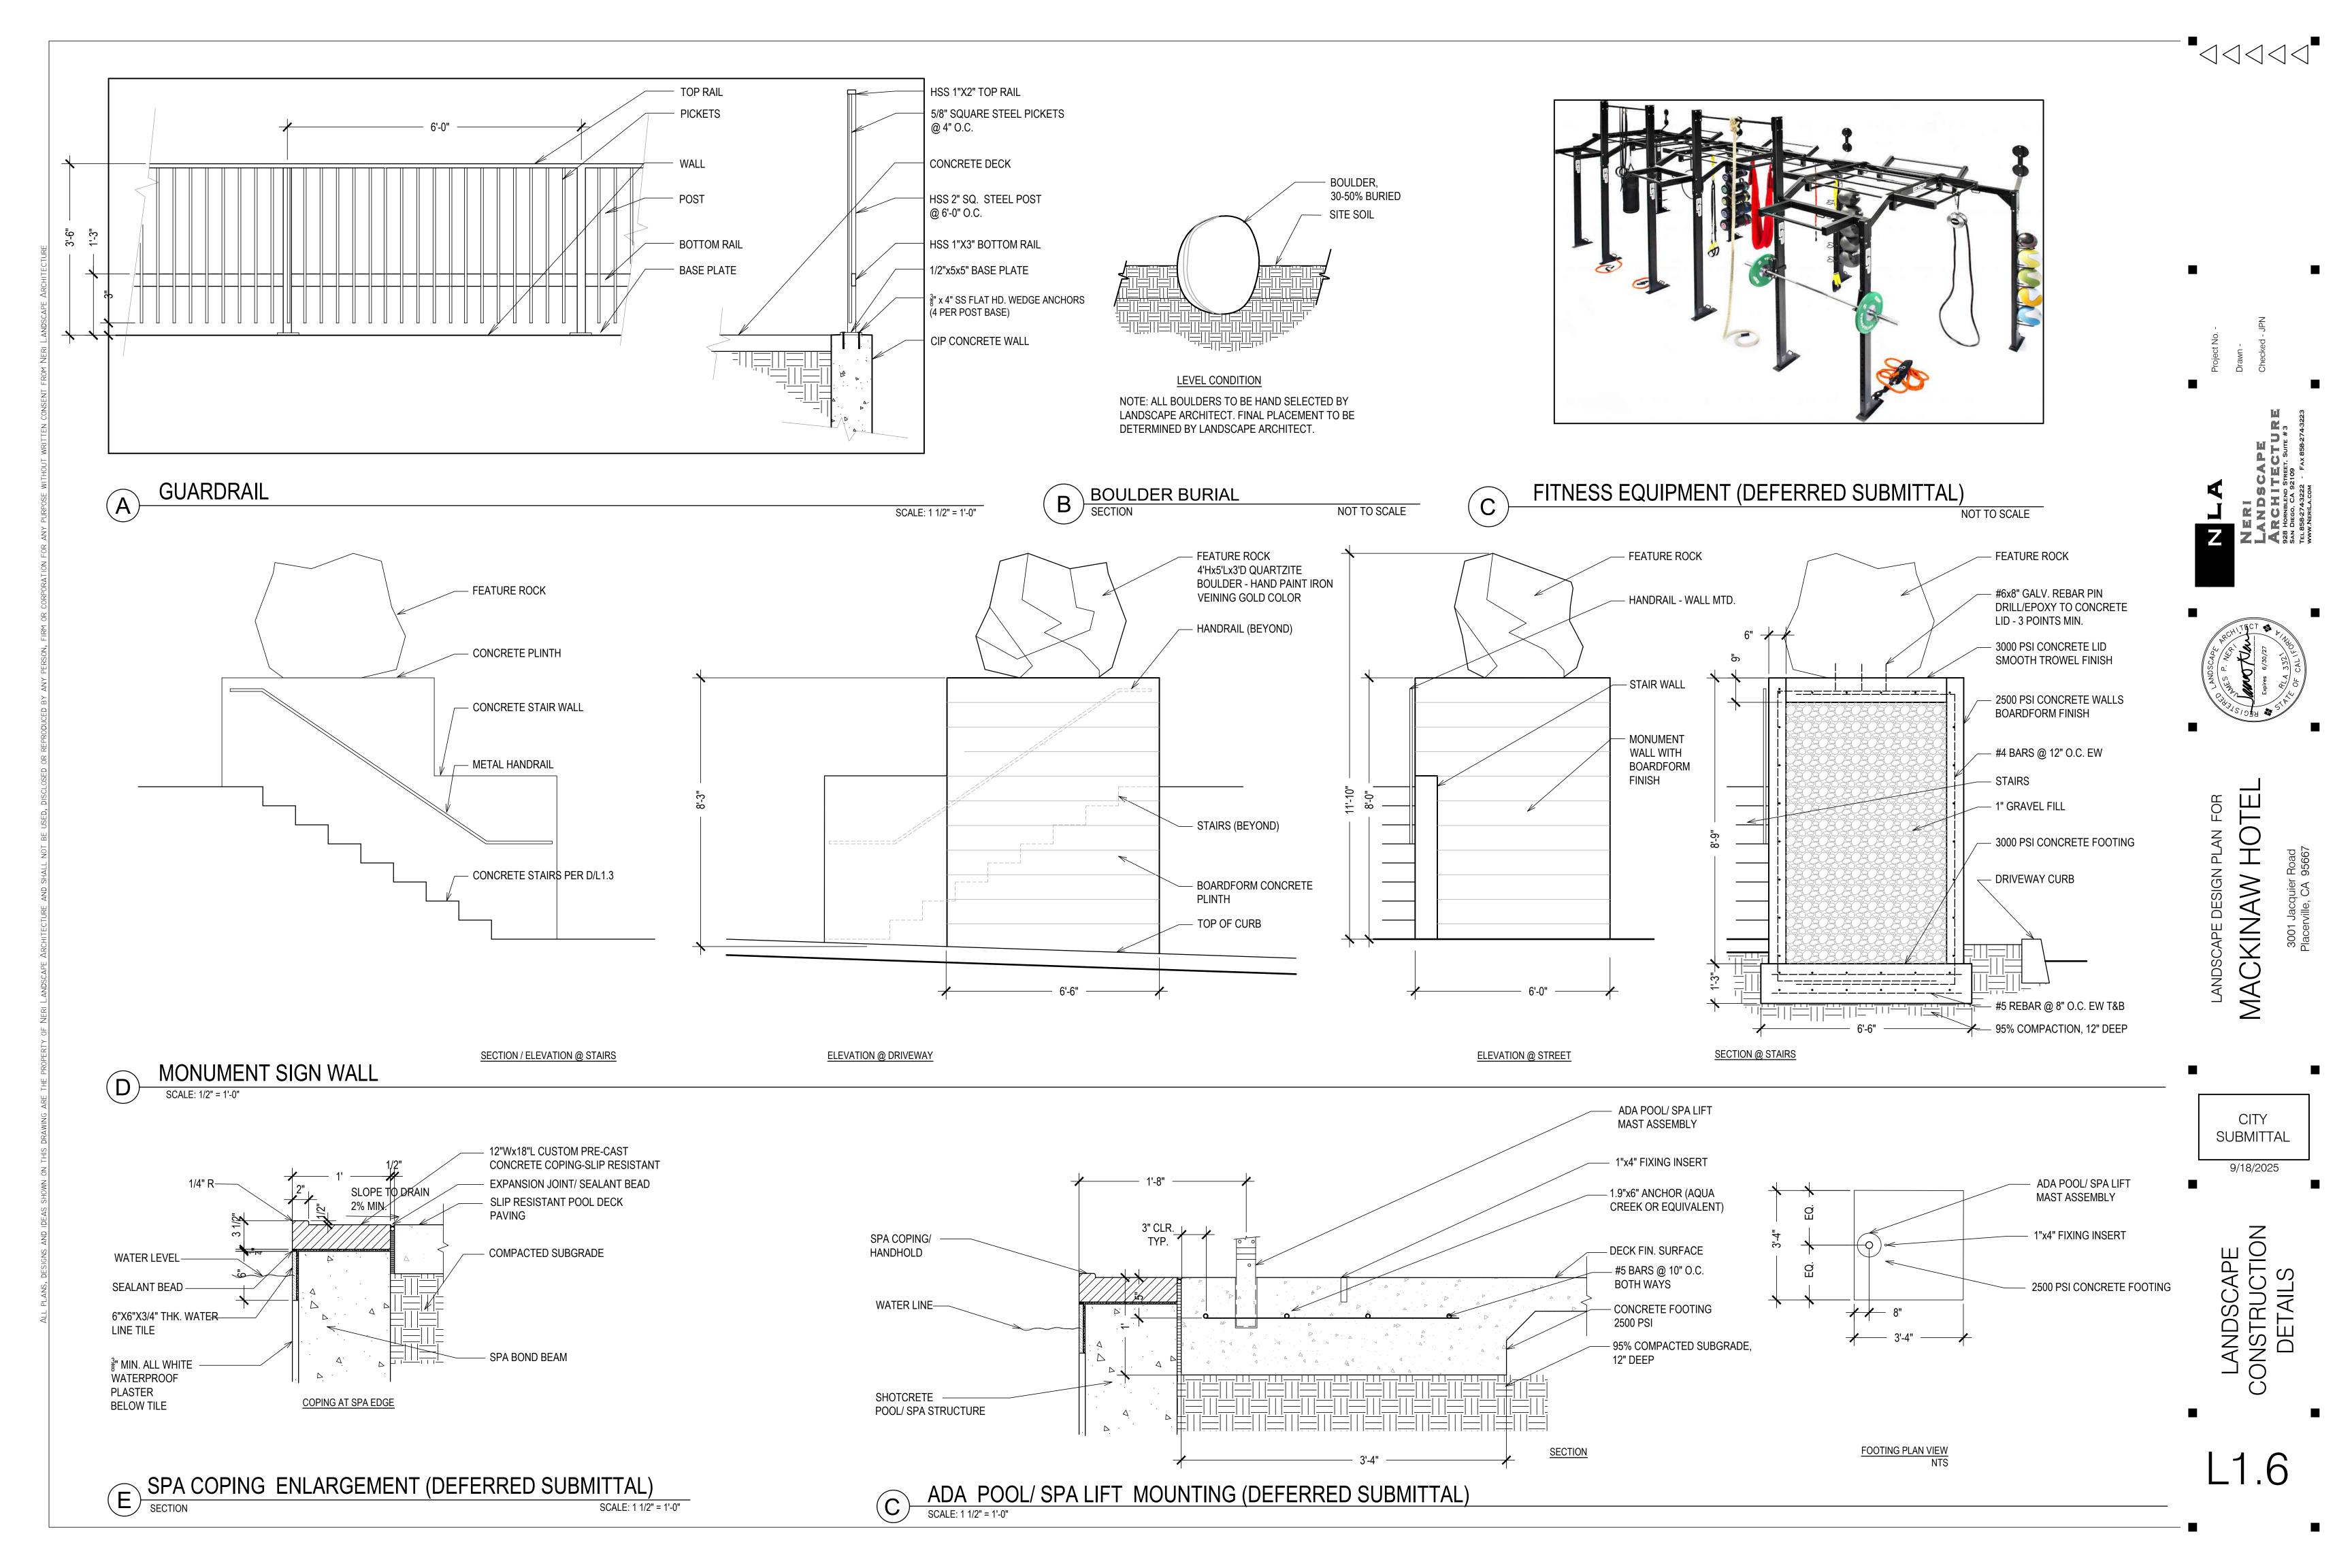

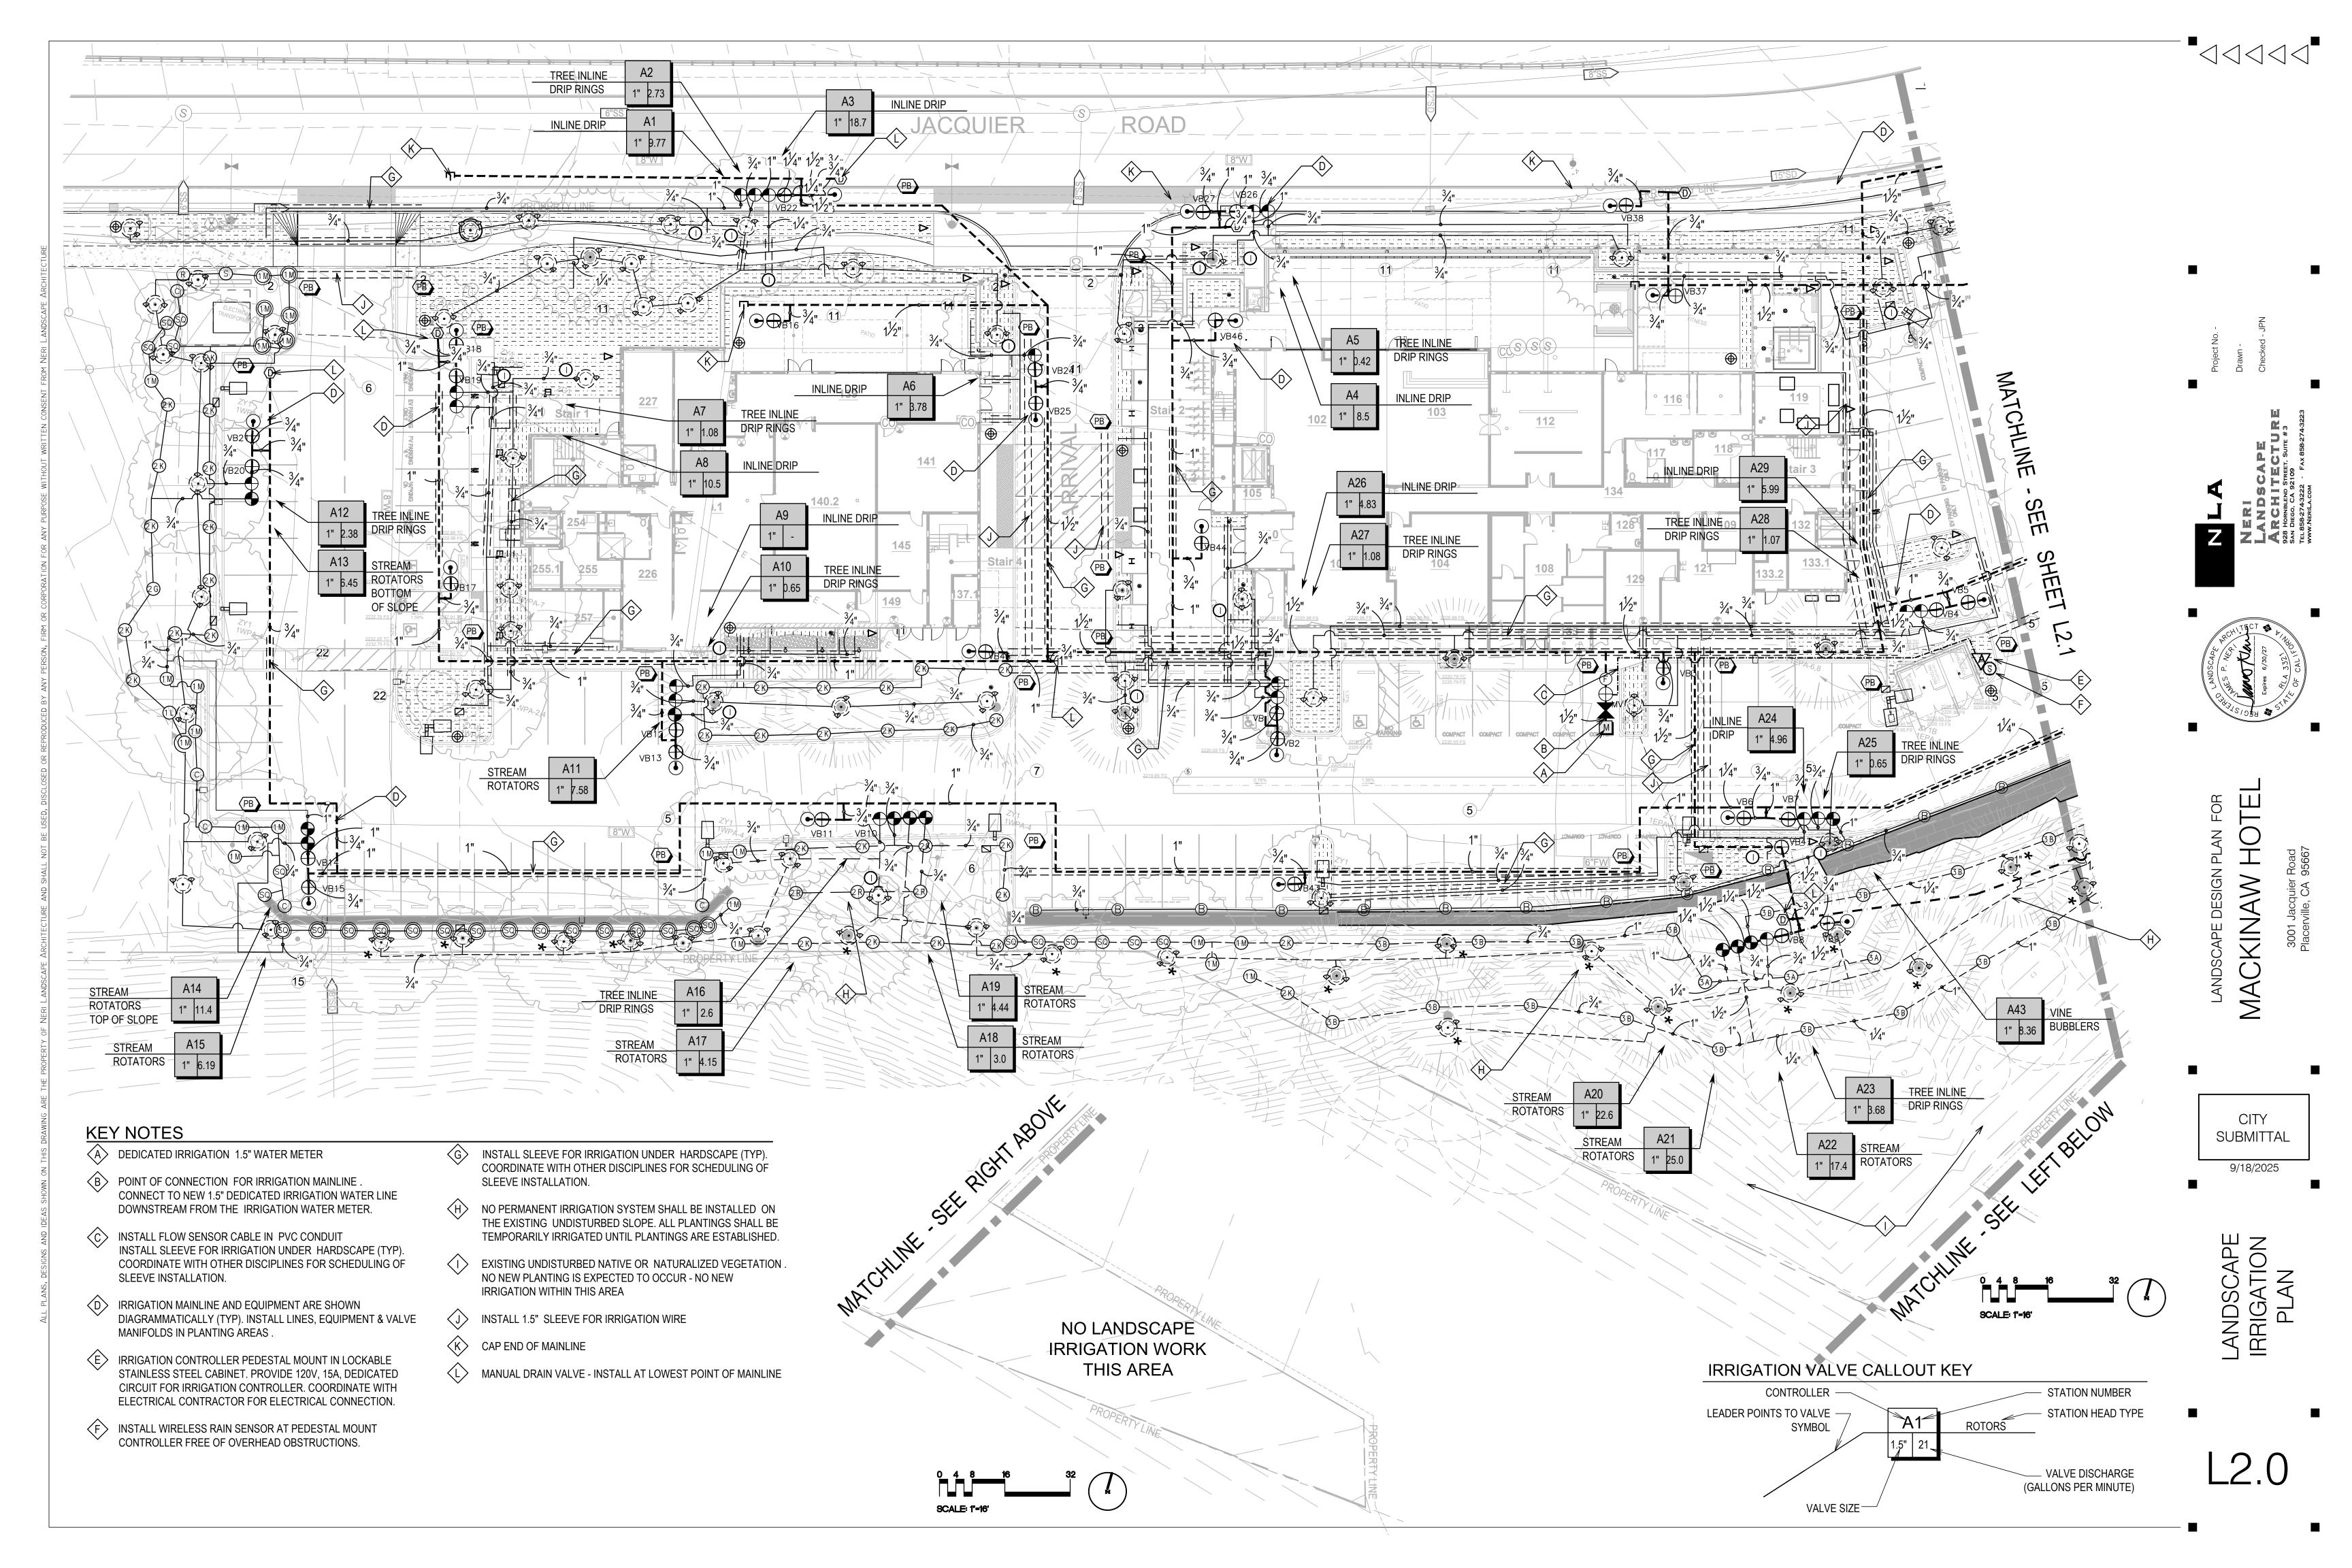

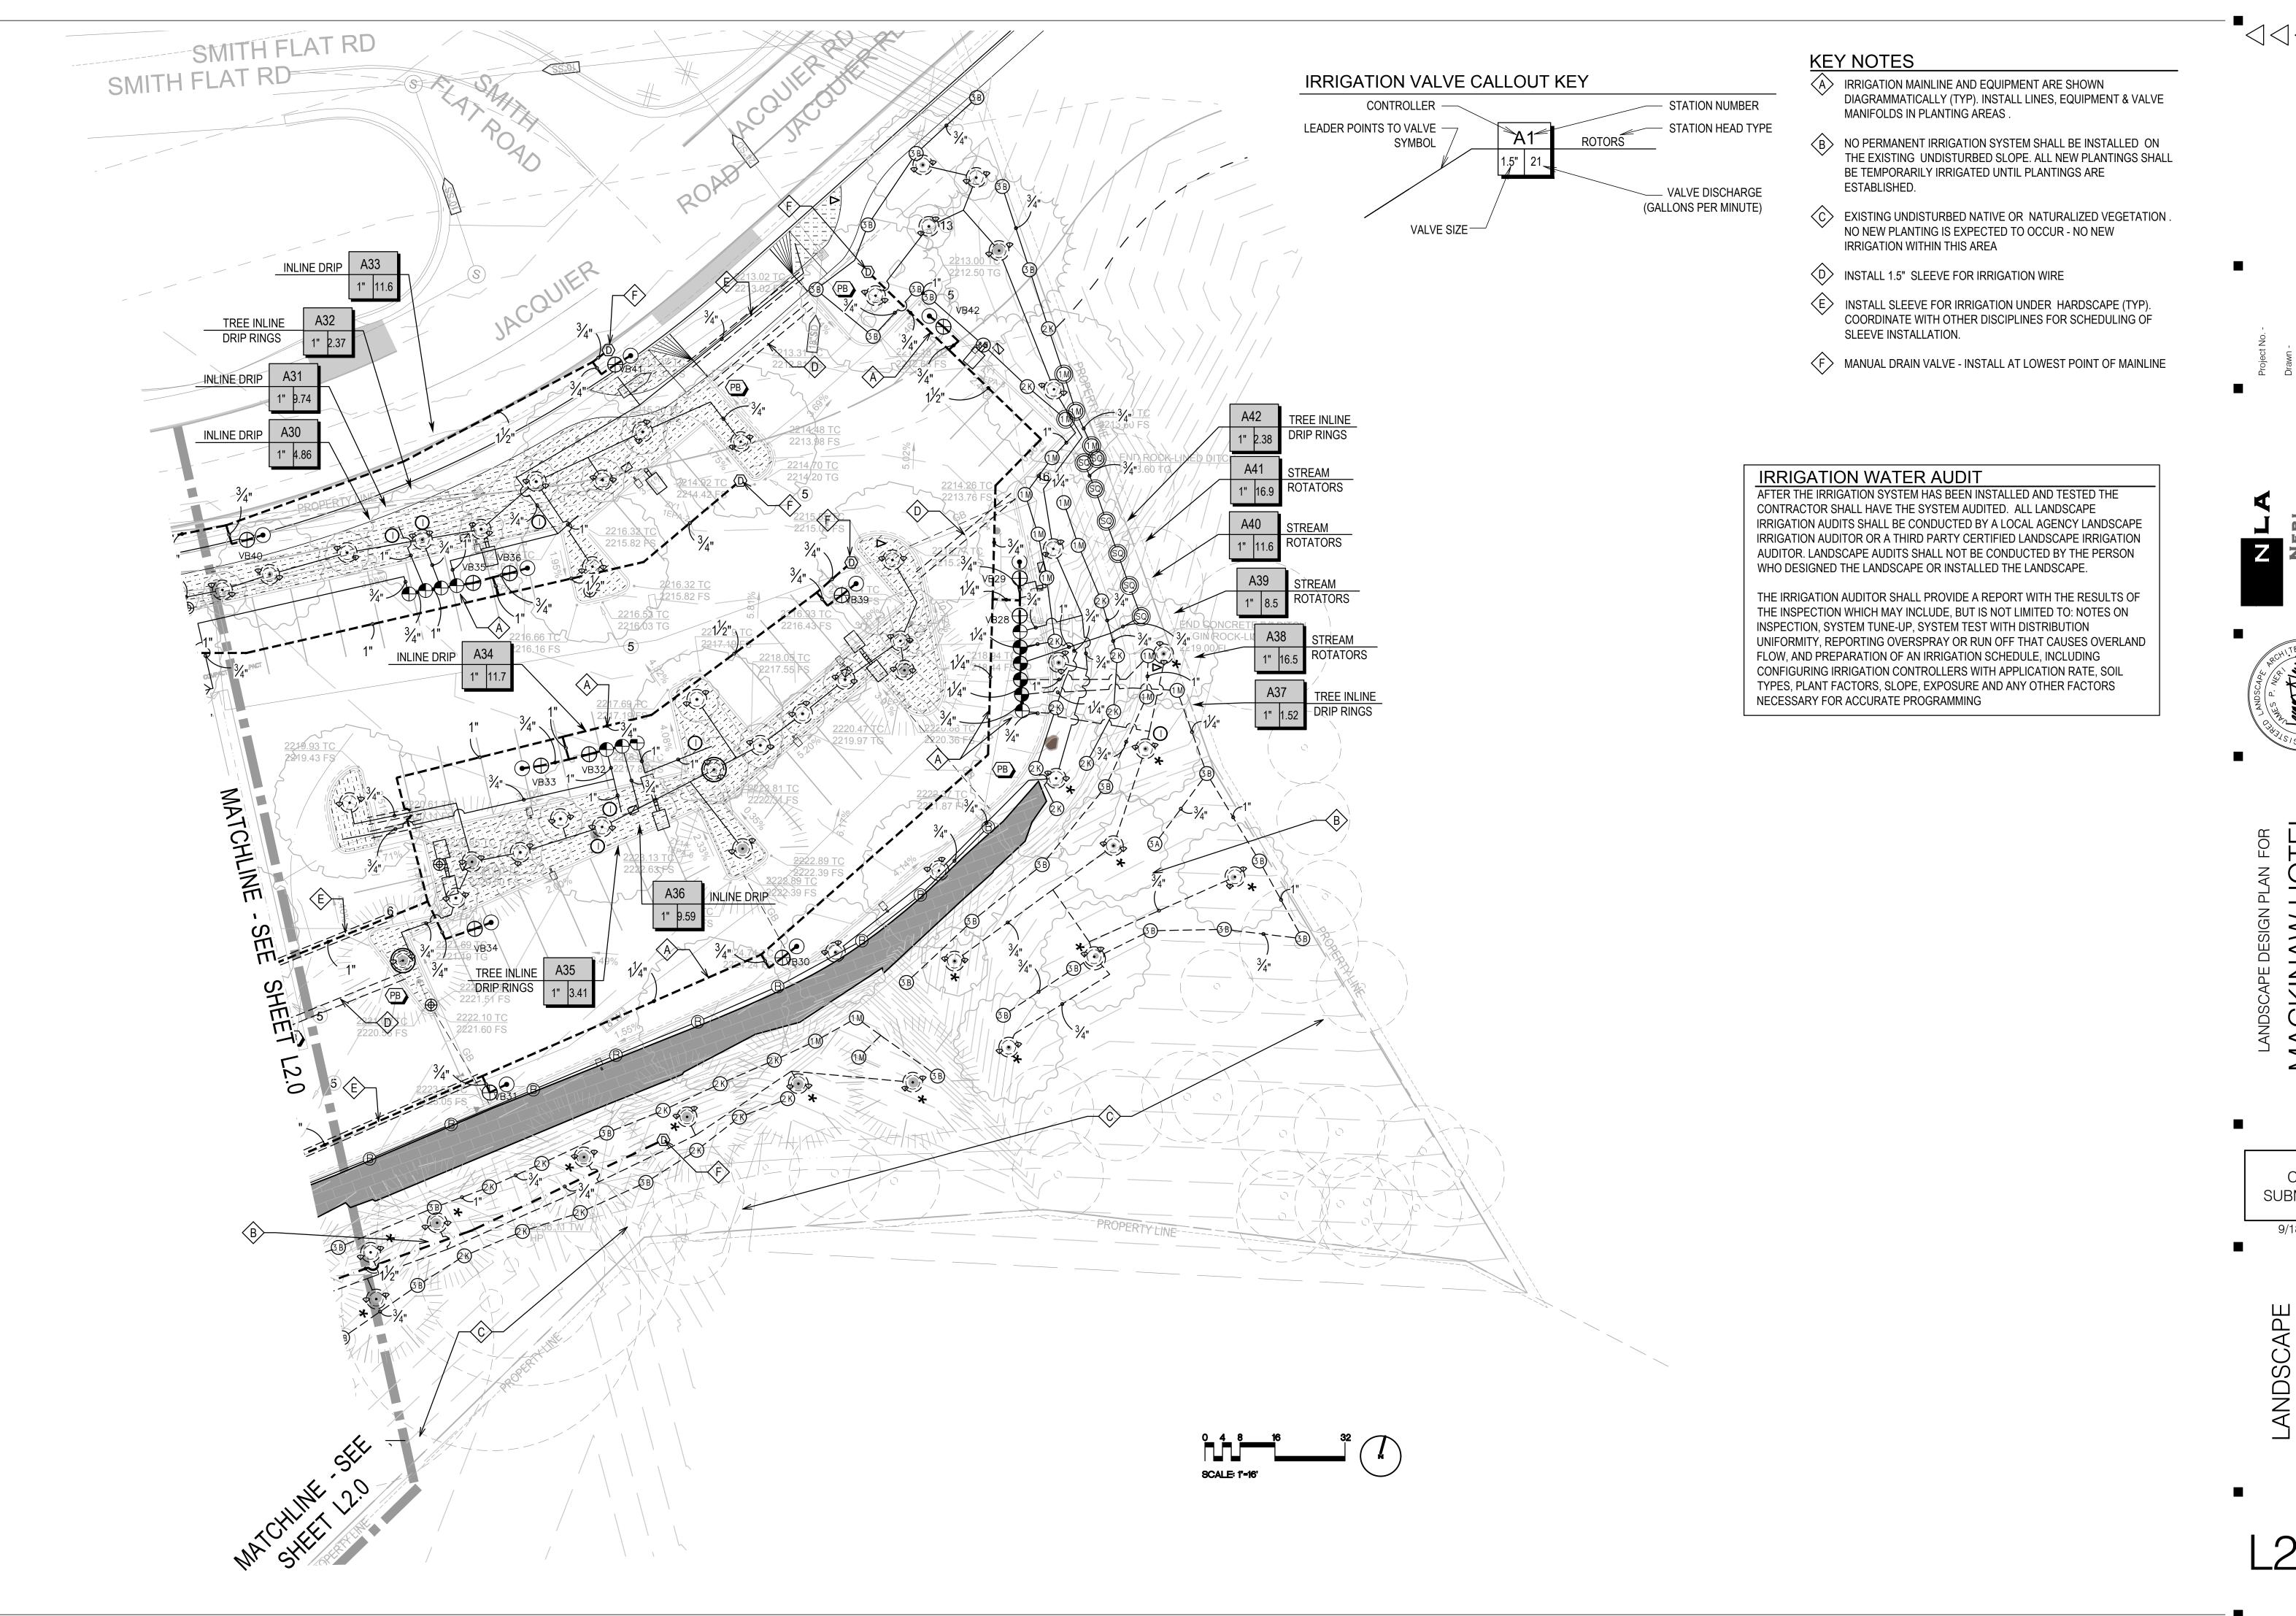

MACKINAW

SUBMITTAL

SYMBOL	DESCRIPTION	MANUFACTURER / MODEL	REMARKS	DETAIL
M	DEDICATED 1.5" IRRIGATION METER		SEE CIVIL PLANS	
POC1	POINT OF CONNECTION		VERIFY STATIC PSI AVAILABLE	
\	AUTOMATIC CONTROLLER	HUNTER I2C-5400-SS 54 STATION OUTDOOR MODULAR CONTROLLER WITH FOUR ICM-800 & ONE ICM-2200 MODULES. LOCKABLE STAINLESS STEEL CABINET.	INSTALL CONTROLLER IN LOCATION PER PLAN	A/L2.3
×	REDUCED PRESSURE BACKFLOW PREVENTER	FEBCO 825YA 1.5" BACKFLOW PREVENTER	BACKFLOW ENCLOSURE: STRONG BOX BC-30CR LOW PROFILE EXPANDED METAL COVER, GREEN COLOR	B,C/L2.3
\bigoplus_{MV}	MASTER VALVE	SUPERIOR CONTROLS: 3100150 (1.5" NORMALLY OPEN)	CONNECT TO LAST STATION ON CONTROLLER	E/L2.3
F	FLOW SENSOR	HUNTER FLOW-CLIK FCT-150	1.5" SCH 40 SENSOR BODY	D/L2.3
	PVC CONDUIT WITH FLOW SENSOR CABLE	PACIFIC WESTERN PIPE OR EQUAL	FLOW SENSOR CABLE: ARIZONA ELECTRIC, AEF #9516-2SP 2-CONDUCTOR SHIELDED CABLE IN 1-1/4" CONDUIT	F/L2.3
<u>(§)</u>	RAIN SENSOR	HUNTER WSS-SEN WIRELESS	MOUNT TRANSMITTER AT TRASH ENCLOSURE ROOF FREE FROM OVERHEAD OBSTRUCTION	A/L2.3
•	REMOTE CONTROL VALVE	HUNTER: ICV-101G-FS-AS-ADJ	VALVE SIZE PER PLAN	E/L2.3
igoplus	REMOTE CONTROL VALVE & REGULATOR/FILTER ASSEMBLY FOR DRIP	HUNTER ICZ-101-25 1" VALVE WITH FILTER SYSTEM FOR DRIP, PRESSURE REGULATED 40 PSI	DRIP CONTROL ZONE KIT. 1" ICV GLOBE VALVE WITH 1" HY100 FILTER SYSTEM. PRESSURE REGULATION: 40PSI. FLOW RANGE: 0.5 GPM TO 15 GPM. 150 MESH STAINLESS STEEL SCREEN.	E/L2.4
\bigoplus_{BV}	ISOLATION VALVE	DURA T1-XXXW (AT MANIFOLDS, 2" & SMALLER)	SIZE SAME AS MAINLINE, WHITE COLOR	D/L2.3
•	QUICK COUPLER ASSEMBLY	QUICK COUPLER: RAINBIRD 44-LRC KEY: RAINBIRD 44K SWIVEL: RAINBIRD SH-1	PROVIDE (2) QUICK COUPLER KEYS, (2) HOSE SWIVELS	H/L2.3
(D)	MANUAL DRAIN VALVE	DURA T1-XXXW (AT MANIFOLDS, 2" & SMALLER)	SIZE SAME AS MAINLINE, WHITE COLOR	K/L2.4
IO SYMBOL	CONTROL WIRE (CONVENTIONAL)	DIRECT BURIAL WIRE	14 GAUGE PILOT: 12 GAUGE COMMON	K/L2.3
	PVC SLEEVE	PACIFIC WESTERN PIPE OR EQUAL	SCH 80 UNDER ROADS, SCH 40 UNDER WALKS 2 X DIAMETER OF SLEEVED PIPE: 2" MINIMUM	J/L2.3
	MAINLINE (PRESSURE) PIPE BELOW GRADE MAINLINE (PRESSURE) PIPE	PACIFIC WESTERN PIPE OR EQUAL PERMANENT BELOW GRADE COLOR: WHITE; SYMBOL: DASHED LINE TEMPORARY ABOVE GRADE COLOR: UV RESISTANT BROWN	SCH 40 FOR LINES 2" AND SMALLER, CLASS 315 FOR PIPES 2-1/2" AND LARGER	I/L2.3 C/L2.4
	ABOVE GRADE LATERAL LINE PIPE	PACIFIC WESTERN PIPE OR EQUAL PERMANENT BELOW-GRADE COLOR: WHITE SYMBOL: CONTINUOUS LINE TEMPORARY ABOVE-GRADE COLOR: UV RESISTANT BROWN SYMBOL: DASH DOT LINE	SCH 40 FOR LINES 1.5" AND SMALLER (NO ½" PIPE), CLASS 315 FOR PIPES 2" AND LARGER	I/L2.3 C/L2.4
	SUB-SURFACE DRIPLINE AROUND TREE - DOUBLE RING	RAINBIRD: XFS-06-12-XXX EMITTERS 0.6 GPH @ 12" O.C. FITTINGS: RAINBIRD XF DRIPLINE INSERT FITTINGS	SUB-SURFACE (4" BELOW FINISH GRADE) INCLUDES COPPERSHIELD TECHNOLOGY, CONTRACTOR TO SPECIFY LENGTH OF TUBING WHEN ORDERING, CONTRACTOR TO ASSEMBLE IN FIELD	C/L2.
(<u>*</u>)*	ON-GRADE DRIPLINE AROUND TREE - DOUBLE RING - TEMPORARY ABOVE GRADE	RAINBIRD: XFCV-06-12 EMITTERS: 0.6 GPH @ 12" O.C. FITTINGS: RAINBIRD XF DRIPLINE INSERT FITTINGS	RAINBIRD XFCV DRIPLINE WITH HEAVY DUTY CHECK VALVE FOR ELEVATION CHANGES. CONTRACTOR TO SPECIFY LENGTH OF TUBING WHEN ORDERING, CONTRACTOR TO ASSEMBLE IN FIELD	D/L2.
Ф 0.5	DRIP EMITTER FOR TREES	RAINBIRD: XERIBUG EMITTER XB-05PC	INSTALL 2 AT EACH TREE. CONNECT TO BUG CAP WITH ¹ / ₄ " DISTRIBUTION TUBING AND STAKE ABOVE GRADE	C/L2.
	SUB-SURFACE DRIPLINE & FITTINGS	RAINBIRD XFS-CV-06-12-XXX FITTINGS: RAINBIRD XF DRIPLINE INSERT FITTINGS	XFS-CV SUB-SURFACE (4" BELOW FINISH GRADE) PRESSURE COMPENSATING LANDSCAPE DRIPLINE W/ COPPER SHIELD TECHNOLOGY WITH QF DRIPLINE HEADER. 0.6GPH EMITTERS AT 12" O.C. DRIPLINE LATERALS SPACED AT 12 "APART, WITH EMITTERS OFFSET FOR TRIANGULAR PATTERN. UV RESISTANT. CONTRACTOR TO SPECIFY LENGTH OF TUBING WHEN ORDERING.	A,B/L
⊕	AIR VACUUM RELIEF VALVE	RAINBIRD ARV050	INSTALL AT THE HIGHEST POINT OF EACH INDIVIDUAL VALVE ZONE	I/L2.4
\triangleright	FLUSH VALVE ASSEMBLY	RAINBIRD MDCFCAP	INSTALL IN A BOX AT THE FLUSH END OF SYSTEM	J/L2.4
	DRIP OPERATION INDICATOR	RAINBIRD OPERIND	INSTALL AT THE FLUSH END OF SYSTEM	H/L2.
NO SYMBOL	VALVE BOXES	CARSON 1419-12 WITH BOLT DOWN LOC-KIT: PLASTIC VALVE BOX WITH BOLT DOWN, COLOR: GREEN COLOR ISO. & MANUAL DRAIN VALVE: CARSON 910 WITH BOLT DOWN PLASTIC ISOLATION VALVE BOX; COLOR: GREEN	RCV: 11 $\frac{7}{8}$ "x17", 12" DEEP, HEAT BRAND VALVE NUMBER IN LID ISO VALVE BOX/QC :10" DIA. x 10" DEEP, HEAT BRAND WITH 'ICV'/'QC' IN LID	G/L2.
	PULL BOXES	CARSON 809 : PLASTIC VALVE BOX WITH BOLT	SIZE: 7" DIA. X 9" DEEP, HEAT BRAND WITH 'PB' IN LID.	A/L2.4

IRRIGATION STREAM ROTATOR HEAD SCHEDULE

							GALL	ONS PER	MINUIE	-	
ARC	SYM	DESCRIPTION	MANUFACTURER/ MODEL NUMBER	RAD. (FT.)	PSI	360 °	270 °	210 °	180 °	90 °	DETAIL
		Taurana	HIINTED DDOS OA DDSAO CV MD8OOSD OO (LAWN)								
90°-210°	<u>(Q</u>	SHORT DISTANCE POP-UP STREAM ROTOR	HUNTER, PROS-04-PRS40-CV-MP800SR-90 (LAWN) HUNTER, PROS-12-PRS40-CV-MP800SR-90 (SHRUB)	9'	40			0.49	0.42	0.23	B/L2.4
360°	(SF)	SHORT DISTANCE POP-UP STREAM ROTOR	HUNTER, PROS-04-PRS40-CV-MP800SR-360 (LAWN) HUNTER, PROS-12-PRS40-CV-MP800SR-360 (SHRUB)	9'	40	0.78					B/L2.4
210°-270°	11	SHORT DISTANCE POP-UP STREAM ROTOR	HUNTER, PROS-04-PRS40-CV-MP1000-210 (LAWN) HUNTER, PROS-12-PRS40-CV-MP1000-210 (SHRUB)	14'	40		0.57	0.43			B/L2.4
90°-210°	1M	SHORT DISTANCE POP-UP STREAM ROTOR	HUNTER, PROS-04-PRS40-CV-MP1000-90 (LAWN) HUNTER, PROS-12-PRS40-CV-MP1000-90 (SHRUB)	14'	40			0.43	0.37	0.19	B/L2.4
360°	10	SHORT DISTANCE POP-UP STREAM ROTOR	HUNTER, PROS-04-PRS40-CV-MP1000-90 (LAWN) HUNTER, PROS-12-PRS40-CV-MP1000-90 (SHRUB)	14'	40	0.75					B/L2.4
360°	@R	SHORT DISTANCE POP-UP STREAM ROTOR	HUNTER, PROS-04-PRS40-CV-MP2000-360 (LAWN) HUNTER, PROS-12-PRS40-CV-MP2000-360 (SHRUB)	19'-20'	40	1.47					B/L2.4
210°-270°	20	SHORT DISTANCE POP-UP STREAM ROTOR	HUNTER, PROS-04-PRS40-CV-MP2000-210 (LAWN) HUNTER, PROS-12-PRS40-CV-MP2000-210 (SHRUB)	19'-20'	40		1.10	0.86			B/L2.4
90°-210°	2K	SHORT DISTANCE POP-UP STREAM ROTOR	HUNTER, PROS-04-PRS40-CV-MP2000-90 (LAWN) HUNTER, PROS-12-PRS40-CV-MP2000-90 (SHRUB)	19'-20'	40			0.86	0.74	0.40	B/L2.4
360°	3A	SHORT DISTANCE POP-UP STREAM ROTOR	HUNTER, PROS-04-PRS40-CV-MP3000-360 (LAWN) HUNTER, PROS-12-PRS40-CV-MP3000-360 (SHRUB)	30'	40	3.64					B/L2.4
210°-270°	3	SHORT DISTANCE POP-UP STREAM ROTOR	HUNTER, PROS-04-PRS40-CV-MP3000-210 (LAWN) HUNTER, PROS-12-PRS40-CV-MP3000-210 (SHRUB)	30'	40		2.73	2.12			B/L2.4
90°-210°	3B	SHORT DISTANCE POP-UP STREAM ROTOR	HUNTER, PROS-04-PRS40-CV-MP3000-90 (LAWN) HUNTER, PROS-12-PRS40-CV-MP3000-90 (SHRUB)	30'	40			2.12	1.82	0.86	B/L2.4

ARC	SYM	DESCRIPTION	MANUFACTURER/ MODEL NUMBER	(FT.)	PSI	105 °	90 °	45 °	DETAIL
45°-105°	©	SHORT DISTANCE POP-UP STREAM ROTOR	HUNTER, PROS-04-PRS40-CV-MPCORNER (LAWN) HUNTER, PROS-12-PRS40-CV-MPCORNER (SHRUB)	14'	40	0.45	0.39	0.19	B/L2.4

(S) DOUBLE RING ON HEAD SYMBOL INDICATES PRS30 BODY IS REQUIRED FOR REDUCED RADIUS UNDER 10'

SPRAY HEAD SCHEDULE

SYMBOL	DESCRIPTION	MANUFACTURER/ MODEL NUMBER	PSI / RADIUS (FT.) / DISCHARGE (GPM)	DETAIL
B	POP-UP DUAL-STREAM BUBBLER NOZZLE	HUNTER, PROS-04-PRS30-CV-5-CST-B	30 / 1'x5' / 0.38	B/L2.4

GENERAL NOTES

1. IRRIGATION SYSTEMS ARE TO BE INSTALLED AS SHOWN ON THE PLANS, AS DIRECTED, IN ACCORDANCE WITH CURRENT LOCAL PLUMBING CODES AS OF THE APPROVED DATE OF THESE PLANS.

2. THE CONTRACTOR SHALL MAKE SURE ALL LANDSCAPED AREAS AFFECTED BY THIS CONSTRUCTION RECEIVE 100% IRRIGATION COVERAGE.

3. IRRIGATION MAINLINE AND EQUIPMENT ARE SHOWN DIAGRAMMATICALLY. THE CONTRACTOR SHALL INSTALL EQUIPMENT IN PLANTING AREAS UNLESS APPROVED IN WRITING BY THE LANDSCAPE ARCHITECT.

4. THE CONTRACTOR SHALL VERIFY EXACT LOCATION OF ALL UNDERGROUND UTILITIES, STRUCTURES, AND EXISTING IRRIGATION EQUIPMENT IN WORK AREA PRIOR TO ORDERING ANY IRRIGATION MATERIALS AND PROCEEDING WITH THE INSTALLATION OF THE IRRIGATION SYSTEM. IF A CONFLICT EXISTS BETWEEN SUCH OBSTACLES AND THE PROPOSED WORK, CONTRACTOR SHALL PROMPTLY NOTIFY THE LANDSCAPE ARCHITECT TO ARRANGE FOR REQUIRED RE-LOCATIONS PRIOR TO START OF CONSTRUCTION. IF THE CONTRACTOR FAILS TO NOTIFY THE LANDSCAPE ARCHITECT SHOULD THE LOCATIONS BE FOUND DIFFERENT, THE CONTRACTOR SHALL BE SOLELY RESPONSIBLE FOR ANY CHANGES AND ADDITIONS THAT MAY OCCUR TO THE SYSTEMS.

5. THE CONTRACTOR SHALL INSTALL MANIFOLDS (QUICK COUPLERS/ HOSE BIBS AND REMOTE CONTROL VALVES) ADJACENT TO WALKS AND CURBS (12" MAX. FROM SUCH EDGES) IN PLANTING AREAS. IN NO CASE SHALL VALVES BE LOCATED IN PAVED AREAS, UNLESS APPROVED IN WRITING BY THE LANDSCAPE ARCHITECT.

6. ALL LATERAL END RUNS ARE 3/4" SIZE UNLESS INDICATED OTHERWISE.

7. ALL IRRIGATION LINES PASSING UNDER PAVING, THROUGH WALLS, STRUCTURES, ETC. SHALL BE SLEEVED AS SPECIFIED. SLEEVES SHALL BE 2 TIMES THE DIAMETER OF PIPE TO BE SLEEVED MINIMUM.

8. CONTROL WIRES PASSING UNDER ROADS, THROUGH WALLS, STRUCTURES, ETC. SHALL BE INSTALLED AS SPECIFIED IN CONDUIT SLEEVES AT LEAST 2 TIMES THE DIAMETER OF WIRE BUNDLE (2" SIZE MINIMUM). KEEP CONDUIT SEPARATE FROM WATER LINE SLEEVES.

9. THE CONTRACTOR SHALL BE RESPONSIBLE FOR DETERMINING THE EXTENT OF ANY SIMULTANEOUS AND ESSENTIAL WORK BY OTHERS ON THE SITE. CONTRACTORS SHALL COORDINATE THEIR OPERATIONS AND SHALL COOPERATE TO MINIMIZE INTERFERENCE.

10. THE CONTRACTOR SHALL BE RESPONSIBLE FOR NOTING AND DIMENSIONING FROM FIXED OBJECTS, THE EXACT LOCATION OF REMOTE CONTROL WIRING ROUTE, MAINLINE ROUTE, VALVES AND ALL OTHER MAJOR IRRIGATION EQUIPMENT ON THE "AS-BUILT" DRAWINGS. SEE ALSO SPECIFICATIONS.

11. IN THE LOCATIONS WHERE THE INLINE DRIP TUBING SHARES A TRENCH WITH MAINLINE AND LATERAL LINES BACKFILL TRENCH WITH MOISTURE-CONDITIONED SOIL TO AT LEAST OPTIMUM MOISTURE CONTENT AND COMPACT TO AT LEAST 90 PERCENT RELATIVE COMPACTION. IN TRENCHES WITH STACKED PIPING, IF THE REQUIRED COMPACTION CANNOT BE ATTAINED USING SOIL BACKFILL, USE A SLURRY BACKFILL, WITH A 2- TO 3-SACK SAND-CEMENT SLURRY, WITH THE UPPER 12 INCHES OF THE TRENCH BACKFILLED WITH SOIL, MOISTURE- CONDITIONED TO AT LEAST OPTIMUM MOISTURE CONTENT AND COMPACTED TO AT LEAST 90 PERCENT RELATIVE COMPACTION, PER GEOSOILS' GEOTECHNICAL REPORT.

12. PROVIDE EXTRA WIRES PLUS ONE EXTRA COMMON WIRE CONTINUOUS FROM CONTROLLER TO FURTHEST VALVE IN EACH CLUSTER. PROVIDE WATERPROOF IDENTIFICATION TAG ON EXTRA

WATER SOURCE

1. THE IRRIGATION POINT OF CONNECTION (P.O.C.) SHALL BE MADE BY THE CONTRACTOR DOWNSTREAM OF THE EXISTING DOMESTIC WATER METER. RECLAIMED WATER IS NOT AVAILABLE AT THE SITE.

2. CONTRACTOR SHALL VERIFY THE EXACT LOCATION AND THE STATIC WATER PRESSURE OF 72 PSI AT POINTS OF CONNECTION PRIOR TO ORDERING ANY IRRIGATION MATERIALS AND PROCEEDING WITH INSTALLING IRRIGATION SYSTEM.

IF THE CONTRACTOR FAILS TO NOTIFY THE LANDSCAPE ARCHITECT SHOULD THE STATIC WATER PRESSURE FOUND BE DIFFERENT, CONTRACTOR SHALL BE RESPONSIBLE FOR ANY CHANGES AND ADDITIONS THAT MAY OCCUR TO THE SYSTEMS.

3. THE IRRIGATION SYSTEM IS DESIGNED TO OPERATE AT 40 PSI AT STREAM ROTATORS & 30 PSI AT THE DRIP IRRIGATION LINES.

CONTROLS

Flow Available at POC:

1. SYSTEMS OF THIS PROJECT ARE CONTROLLED BY SOLID STATE IRRIGATION CONTROLLER WITH SPECIFIED OPTIONS. THE CONTRACTOR SHALL MAINTAIN STRICT COMPLIANCE WITH THE MANUFACTURER'S INSTRUCTIONS FOR PROPER GROUNDING, INSTALLATION AND USE.

2. CONTROLLER LOCATION IS SHOWN DIAGRAMMATICALLY. FINAL LOCATION TO BE APPROVED BY THE OWNER'S REPRESENTATIVE. POWER FOR THE IRRIGATION CONTROLLER SHALL BE PROVIDED BY THE OWNER LOCATED APPROXIMATELY WHERE SHOWN ON THE DRAWINGS. THE CONTRACTOR SHALL BE RESPONSIBLE FOR INSTALLATION OF THE IRRIGATION CONTROLLER.


3. TO PREVENT UNNECESSARY IRRIGATION IN THE EVENT OF SUBSTANTIAL RAINFALL THE IRRIGATION CONTROL SYSTEMS SHALL INCLUDE A RAIN SENSING DEVICE.

CRITICAL ANALYSIS

Generated:	2023-10-27 10:44
P.O.C. NUMBER: 01 Water Source Information:	
FLOW AVAILABLE Water Meter Size: Flow Available	2" 120 GPM
PRESSURE AVAILABLE Static Pressure at POC: Elevation Change: Service Line Size: Length of Service Line: Pressure Available:	105 PSI 5.00 ft 3" 20 ft 103 PSI
DESIGN ANALYSIS Maximum Station Flow:	30 GPM

Residual Flow Available:	90 GPM
Pressure Req. at Critical Station:	60.0 PSI
Loss for Fittings:	1.45 PSI
Loss for Main Line:	14.5 PSI
Loss for POC to Valve Elevation:	0 PSI
Loss for Backflow:	12.1 PSI
Loss for Master Valve:	0.53 PSI
Loss for Water Meter:	0.8 PSI
Critical Station Pressure at POC:	89.4 PSI
Pressure Available:	103 PSI
Residual Pressure Available:	13.6 PSI

120 GPM

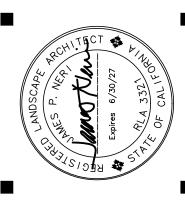

CKINAW

CITY SUBMITTAL

9- 1" PVC CONDUIT AND LONG SWEEP ELL.

14- GROUNDING LUG TERMINAL WITH CONNECTION

10- 3/4" DIA. x96" ELEC. GROUND ROD.

11- EPOXY SEALANT AROUND EDGES.

12- MOUNTING HARDWARE

13- BACKBOARD

TO GROUND ROD.

4- POURED CONCRETE BASE

5- PVC LONG SWEEP ELL- SIXE AS REQUIRED 6- DIRECT BURIAL REMOTE CONTROL WIRES.

IRRIGATION CONTROLLER - OUTDOOR PEDESTAL MOUNT


PVC PRESSURE PIPE FOR MCV

10. PEA GRAVEL SUMP, 3" DEEP MIN

12. FLUSH IN TURF, 1" IN GROUNDCOVER

11. UNDISTURBED/ COMPACTED

SUBGRADE

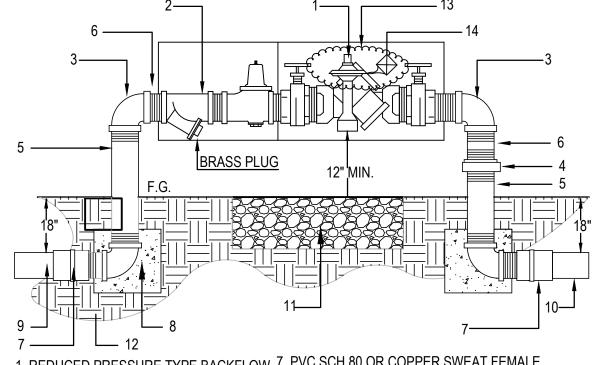

1. REDUCED PRESSURE TYPE BACKFLOW 7. PVC SCH 80 OR COPPER SWEAT FEMALE ADAPTER (DEEP SOCKET) ON SERVICE

PREVENTION DEVICE ASSEMBLY 2. Y' STRAINER W/ 20 MESH INSERT AND 8. CONCRETE FOOTING (1 CU. FT.) PRESSURE REG.

3. BRASS ELL'S (REDUCING IF NEC.)

9. BRASS, TYPE K COPPER OR CL315 PVC FROM METER

1. FLOW SENSOR

EXTRA WIRE)

EXTENSION

2. COMMUNICATION WIRE (COIL W/ 4"

4. BRANDED 17" X 18" VALVE BOX W/

3. WATER PROOF CONNECTORS

5. BRICK OR BLOCK SUPPORTS

6. PEA GRAVEL SUMP 3" DEEP

8. REQUIRED DISTANCE FROM

11. AT FINISH GRADE IN TURF;

12. UNDISTURBED OR COMPACTED

13. TWO (2) CONDUCTOR, SHEILDED

CABLE (AEF 9516-2SP OAE) CONNECT

9. REDUCING FITTING OR HARDWARE

FITTING/HARDWARE

1" IN SHRUB AREA

TO TRANSMITTER

SUBGRADE

I. REMOVE AND REPLACE 3" ASPHALT

2. 90% CLEAN BACKFILL AS REQUIRED

MATERIAL AND COMPACTION

REQUIREMENTS)

3. SOIL SEPARATOR

(REFER TO ENGINEER FOR SPECIFIC

10. PVC PRESSURE MAIN

4. BRASS UNION (RISER SIZE)

5. BRASS RISERS: MAINLINE SIZE (L.A.R.) 12. UNDISTURBED OR COMPACTED SUBGRADE 6. BRASS NIPPLES (NO CLOSE NIPPLES) 13. CHAIN & PAD LOCK / REMOVE HAND WHEELS 14. IDENTIFICATION TAGS AS NEEDED 1. BACKFLOW PREVENTION DEVICE ASSEMBLY SHALL BE INSTALLED IN ACCORDANCE TO


11. PEA GRAVEL SUMP (12"X12"X12")

GOVERNING CODES AND ORDINANCE. 2. WRAP SUBSURFACE BRASS PIPING WITH 10 MILL UPC PIPE WRAP. 3. WINTERIZATION: WRAP BACKFLOW PREVENTER ABOVE-GROUND PIPES WITH BLACK

FOAM INSULATION BACKFLOW PREVENTION DEVICE

NOT TO SCALE

BACKFLOW PREVENTION DEVICE ENCLOSURE SECTION NOT TO SCALE

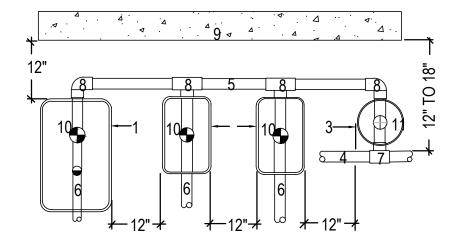

1. JUMBO RECTANGULAR VALVE BOX 20"x14", 7. PVC SCH 80 TEE-SSS OR EL-SS ON MAX 4 VALVES PER VALVE BOX MAINLINE 2. STANDARD RECTANGULAR VALVE BOX 8. PVC SCH 80 TEE-SSS OR EL-SS ON

1. REDUCED PRESSURE TYPE BACKFLOW

LARGER THAN ENCLOSURE FOOTPRINT

3. ENCLOSURE

4. COMPACTED SUBGRADE

PREVENTION DEVICE ASSEMBLY (BY OTHERS)

2. 4" THICK CONCRETE PAD - CONCRETE PAD 2"

17"x12", MAX 3 VALVES PER VALVE BOX 7. PVC PRESSURE MAIN SIZED EQUAL 3. ROUND VALVE BOX 10" DIA. TO SENSOR FOR REQUIRED LENGTH MAX 1 VALVE PER VALVE BOX

4. PVC PRESSURE PIPE - MAINLINE 5. PVC PRESSURE PIPE - MANIFOLD 6. PVC NON-PRESSURE PIPE - LATERAL

10. RCV ASSEMBLY WITH DURA MANIFOLD FITTINGS - SEE OTHER DETAILS 11. RCV MANIFOLD ISOLATION VALVE

9. EDGE OF AREA (CURB, WALK, WALL)


MANIFOLD

A. CONTROL VALVES SHALL BE INSTALLED TO ALLOW ORDERLY ARRANGEMENT OF VALVE BOXES B. LOCATE VALVE ASSEMBLES IN SHRUB OR GROUNDCOVER AREAS WHEN POSSIBLE C. LOCATION OF VALVE ASSEMBLIES SHALL BE STAKED FOR APPROVAL BY LANDSCAPE ARCHITECT PRIOR TO

D. CENTER VALVE BOXES OVER VALVE ASSEMBLY TO FACILITATE ACCESS & MAINTENANCE. E. SET VALVE BOXES AT EQUAL ELEVATIONS WITH TOP AT FINISH GRADE IN TURF AREAS OR ABOVE FINISH GRADE IN SHRUB/GROUNDCOVER AREAS. F. VALVE BOXES SHALL BE SET PARALLEL TO EACH OTHER AND PERPENDICULAR TO EDGE OF AREA.

G. DO NOT DEFORM OR COLLAPSE VALVE BOX BY EXCESSIVE SOIL COMPACTION AROUND VALVE BOX H. SEE ALSO INDIVIDUAL VALVE DETAILS.

G VALVE MANIFOLD & VALVE BOX ORIENTATION NOT TO SCALE

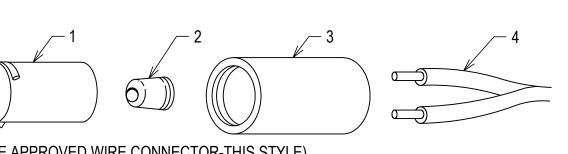

4. WIRES

ASSEMBLY INSTRUCTIONS

B. JOIN WIRES TOGETHER AND APPLY CRIMP SLEEVE.

D. FILL CAP TO BRIM WITH SEALANT AND ALSO APPLY SEALER TO OUTSIDE OF PLUG. E. INVERT BODY AND INSERT PLUG INTO BODY UNTIL IT SNAPS TIGHT

WIRE CONNECTORS NOT TO SCALE

7. PVC SCH 80 FEMALE ADAPTER 1. GATE VALVE OR BALL VALVE


2. VALVE BOX W/EXTENSIONS AS NEEDED (DEEP SOCKET) 8. PVC PRESSURE MAIN (TYP) 3. BRASS UNION W/ BRASS NIPPLE 9. PVC SCH 80 45 DEGREE ELLS (TYP) 4. BRICK OR BLOCK SUPPORTS 10. AT FINISH GRADE IN TURF, 1" IN SHRUBS 5. PEA GRAVEL SUMP 3" DEEP 11. UNDISTURBED/COMPACTED SUBGRADE 6. PVC SCH 80 NIPPLE (T.O.E.)

A. VALVES UP TO 3" DIA. SHALL HAVE MALLEABLE IRON TEE HANDLES. VALVES LARGER THAN 3" DIA. SHALL HAVE SQUARE OPERATING NUTS.

B. (4) 45 DEGREE PVC ELBOW FITTINGS SHALL BE USED TO RAISE BALL/GATE VALVE TO WITHIN 12" OF FINISH GRADE.

C. RW WARNING TAG IF APPLICABLE. MANIFOLD ISOLATION VALVE

NOT TO SCALE

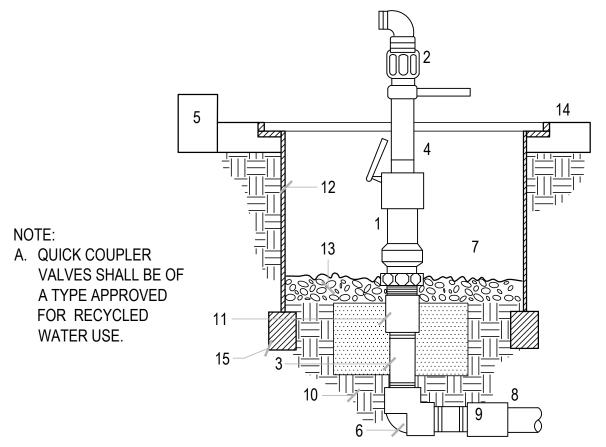

1. QUICK COUPLING VALVE WITH ACME THREAD 8. PVC PRESSURE PIPE

2. QUICK COUPLING KEY W/ SWIVEL HOSE ELL

RED BRASS NIPPLE (LENGTH AS REQ'D) 4. 2" FROM LID BOTTOM

COMPACTED SUBGRADE

5. CONCRETE CURB OR EDGE (WHERE OCCURS) 6. THREADED RED BRASS ELL 7. 1 CU. FT. CONCRETE FOOTING ON

11. THREADED BRASS COUPLING 12. 10" VALVE BOX W/ LID SET FLUSH WITH PAVING SURFACE

13. 1 CU FT PEA GRAVEL SUMP 14. PAVING/PLANTING SURFACE 15. BRICK/CONCRETE SUPPORTS (ONE ON EACH CORNER/SIDE)

10. UNDISTURBED COMPACTED SUBGRADE

9. PVC SCH 40 COUPLING (SxT)


QUICK COUPLING VALVE

NOT TO SCALE

CITY

9/18/2025

CKINAW

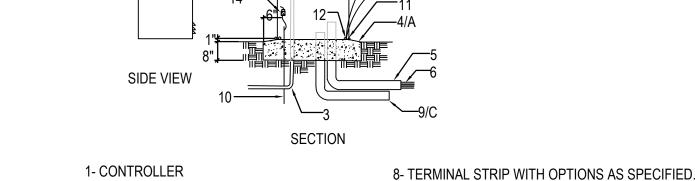

2- ST.STL. CONTROLLER ENCLOSURE 3- 120 VOLT SERVICE IN 1" CONDUIT.

7- POWER SWITCH/ GFI RECEPTACLE

A. 480-C-2000 CONCRETE FOOTING. FORMED AND POURED. SLOPE FOR DARINAGE. FINISH EDGES WITH 1/4" RADIUS

B. MOUNTING & GROUNDING OF CONTROLLER MUST BE IN ACCORDANCE WITH MANUFACTURERS MIN. REQUIREMENTS.

C. CONDUIT TO ADJECENT CONTROLLER FOR COMMUNICATION CABLES IF REQUIRED.

D. DEMENSIONS WILL DEPEND ON ENCLOSURE SIZE REQUIREMENTS.

A IRRIGATION NOT TO SCALE

18" MCV 1. REMOTE OR MASTER CONTOL VALVE 7. PVC PRESSURE PIPE 8. PVC NON-PRESSURE PIPE FOR RCV.

2. WATERPROOF WIRE SPLICE

3. VALVE BOX 4. CONTROL WIRES; BUNDLE AND TAPE (W/ 4 9. BRICK OR CONCRETE SUPPORTS FEET MIN. EXTRA WIRE)

5. PVC SCH 80 NIPPLE (TOE) L.A.R. 6. PVC SCH 40 45[^] ELL (TYP 4X)

NOTES:

A. VALVE BOX LID SHALL BE BRANDED TO IDENTIFY VALVE. B. CONTRACTOR SHALL INCLUDE A CHRISTY'S IRRIGATION I.D. (OAE) TAG ATTACHED TO VALVE BONNET BOLT. TAG SHALL INDICATE CONTROLLER AND STATION NUMBER.

INCLUDE RW WARNING IF APPLICABLE.

MASTER & REMOTE CONTROL VALVE

AND 5x PIPE DIAMETER DOWNSTREAM OF SENSOR.

NOT TO SCALE

FLOW SENSOR

NOT TO SCALE

9 = | | | - (0)

1. PVC NON-PRESSURE PIPE 2. PVC PRESSURE PIPE 3. CONTROL WIRE BUNDLE

4. APPROVED BACKFILL 5. UNDISTURBED SOIL 6. IMPROVED BACKFILL WHERE REQUIRED 7. MINIMUM DISTANCE FROM HARDSCAPE

8. POLYETHYLENE TUBING 9. FLOW SENSOR CABLE IN CONDUIT (WHERE OCCURS)

10. RW WARNING TAPE (WHEN APPLICABLE)

A. TRENCH BOTTOM TO BE FIRM, STABLE AND SMOOTH TO SUPPORT PIPE EVENLY. SUITABLE BEDDING BACKFILL MAY BE NEEDED TO PROVIDE THIS REQUIREMENT. B. THERE SHALL BE NO STONES OR OTHER HARD OBJECTS LARGER THAN 1/2" DIA.

C. PIPE AND WIRE TO BE INSTALLED IN SLEEVES UNDER ALL PAVING AND EXTEND 12"

PAST EDGE OF PAVING. SLEEVES TO BE:

30" TO 36" COVER UNDER ROADS AND DRIVES 18" TO 24" COVER UNDER WALKS **TRENCHING**

NOT TO SCALE

36" @ ROADS 24" @ WALKS 2" CLR'. | |

5 PIPE DIAMETER MIN. ☐ 6 10 PIPE DIAMETER MIN.

A. FOLLOW MANUFACTURERS DIRECTIONS FOR CORRECT INSTALLATION.

B. NO SIZE OR DIRECTION CHANGE WITHIN 10x PIPE DIAMETER UPSTREAM

4. CLEAN PLASTER SAND 5. PRESSURE MAIN LINE W/ SLEEVE 6. LOW VOLTAGE CONTROL WIRES, SLEEVE SIZE AS REQUIRED


7. LATERAL LINE WITH SLEEVE

A. ALL SLEEVES UNDER WALKWAYS TO BE PVC SCH 40 PIPE, ALL SLEEVES UNDER ROADS TO BE PVC SCH 80 PIPE.

B. ALL SLEEVES TO BE SIZED TWICE THE DIA. OF THE PIPE (2" MIN.). C. ALL SLEEVES TO RUN A MIN. OF 12" BEYOND HARDSCAPE EDGES.

TRENCHING UNDER PAVING

NOT TO SCALE

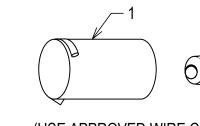


(USE APPROVED WIRE CONNECTOR-THIS STYLE)

1. PLUG 2. CRIMP SLEEVE 3. BODY

A. INSERT WIRES THROUGH HOLES IN BASE OF BODY.

C. DRAW WIRES BACK INTO BODY.

F. BE CERTAIN SEALANT HAS FORMED INTO ALL HOLES IN BODY. G. SEALANT MUST BE VISIBLE OUTSIDE OF PLUG TO PASS INSPECTION.

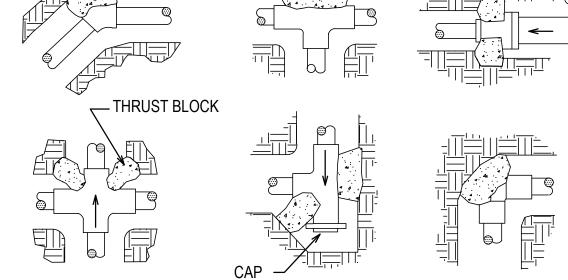

NOTES:

1. ALL PRESSURE PIPE TO BE INSTALLED ACCORDING TO THESE DETAILS UNLESS OTHERWISE NOTED OR DETAILED.

2. THE PORTLAND CEMENT USED FOR CONCRETE THRUST BLOCKS SHALL BE 420-C-2000 CEMENT

3. FOLLOW DIRECTION INDICATED BY ARROW. 4. ALL CHANGES IN DIRECTION OF PIPE SHALL HAVE CONCRETE THRUST BLOCK.

THRUST BLOCKS FOR PRESSURE PIPING PLAN NOT TO SCALE SUBMITTAL

1. ELECTRICAL CONDUIT - 2X WIRE **BUNDLE DIAMETER**

2. CONTROL WIRE 3. WATER PROOF WIRE CONNECTORS

OR EXPANSION LOOPS (LABEL WIRES SUB-GRADE WITH CONTROLLER AND STATION #) 9. 12" x 18" VALVE BOX W/ EXTENSION

4. 18 " MINIMUM (SEE SPECS AND TRENCH DETAIL)

> A. TO BE INSTALLED AT ENDS OF ALL WIRE SLEEVES RUNNING 20 FT. AND LONGER, AT EACH CHANGE OF DIRECTION, AND WITHIN EVERY 300' RUN.

7. 3" DEEP PEA GRAVEL SUMP

8. UNDISTURBED OR COMPACTED

NOT TO SCALE

WIRE PULL BOX

12 3 4 1 6 2" MINIMUM CLEAR

1. REMOTE CONTROL VALVE

6. 12" x 18" VALVE BOX (SEE NOTE

7. FLUSH IN TURF: 1" IN GROUND COVER 8. BRICK SUPPORT (1- EA. CORNER) 2. FILTER 9. SUBGRADE 3. 1" SCH 80 UNION 10. PEA GRAVEL SUMP 3" DEEP 4. SCH 80 NIPPLE LAR (TYP.) 11. PVC PRESSURE PIPE 5. 3/4" PRV OR 1" PRV

BELOW)

A. FOR FLOWS TO 0.5 - 4 G.P.M. USE HUNTER ICZ-101-LF-25 1" DRIP CONTROL VALVE B. FOR FLOWS OF 4-15 G.P.M. USE HUNTER ICZ-101-25 1" DRIP CONTROL ZONE KIT


C. VALVE BOX LID SHALL BE BRANDED TO IDENTIFY VALVE. INCLUDE CHRISTY'S IRRIGATION I.D. TAG ATTACHED TO VALVE BONNET BOLT.

12. SCH 80 FEMALE ADAPTER 13. PVC NON-PRESSURE PIPE

D. TAG SHALL INDICATE CONTROLLER AND STATION NUMBER. E. R.W. WARNING IF REQ.

REMOTE CONTROL VALVE W/ PRESSURE REGULATOR AND FILTER
FOR DRIP IRRIGATION

NOT TO SCALE

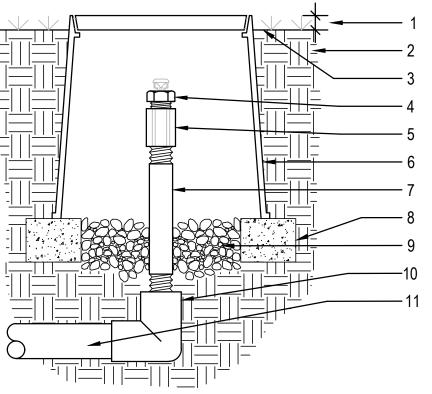

1. 1" ABOVE FINISH GRADE 2. NATIVE SOIL PER SPECIFICATIONS

3. FINISH GRADE

4. AIR/VACUUM RELIEF VALVE 5. 1/2" PVC COUPLING (TxT) 6. 6" ROUND PLASTIC VALVE BOX -HEAT BRAND "AR" ON LID IN 1" HIGH OUTLET


7. 1/2" SCH 80 PVC NIPPLE (LENGTH AS REQUIRED) 8. BRICK SUPPORTS (2 COMMON BRICKS REQUIRED)

9. PEA GRAVEL SUMP (6" DEEP) 10. PVC ELL (SxT) WITH 1/2" THREADED 11. PVC PIPING

CHARACTERS

1. USE ONE AIR/VACUUM RELIEF VALVE FOR EVERY 7 GPM PER ZONE. 2. AIR/VAC TO BE INSTALLED AT HIGHEST LOCAL ELEVATION.

DRIP - AIR/VACUUM RELIEF VALVE NOT TO SCALE

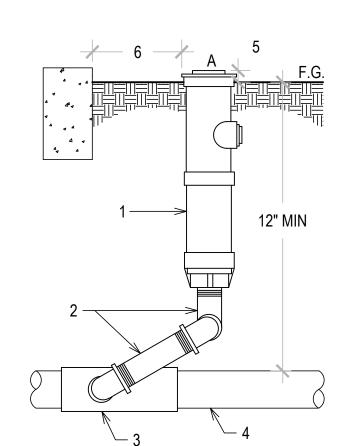

A. RW WARNING CAP IF APPLICABLE.

POP-UP SPRAY HEAD

NOT TO SCALE

1. POP-UP SPRAY HEAD

SHRUB AREAS


2. SWING JOINT ASSEMBLY (3 MARLEX

ST ELLS, 1 SCH 80 NIPPLE) 3. PVC SCH 40 TEE (SST) OR EL (ST) 4. PVC NON-PRESSURE LATERAL 5. AT FINISH GRADE IN TURF; 1" IN

6. DISTANCE FROM HARDSCAPE:

ROTORS - WALKS = 24", WALLS = 24"

SPRAYS - WALKS = 24", WALLS = 24"

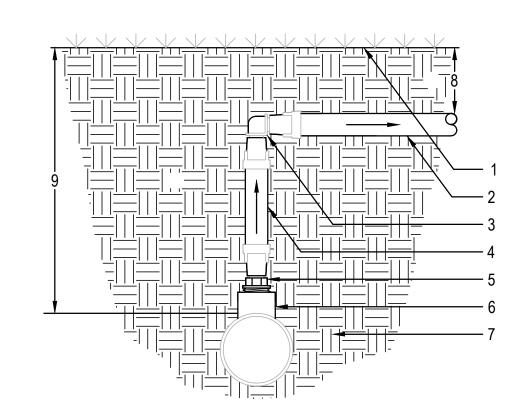

 FINISH GRADE 2. DRIPLINE LATERAL


6. PVC TEE (SxSxT) WITH 1/2" **FPT OUTLET** 7. NATIVE SOIL BACKFILL PER

3. ELL (FEE16) 4. POLY TUBING **SPECIFICATIONS** 5. ADAPTER 8. 4"

9. DEPTH OF PVC MANIFOLD PER SPECIFICATIONS

NOT TO SCALE

DRIP - MANIFOLD ELL CONNECTION

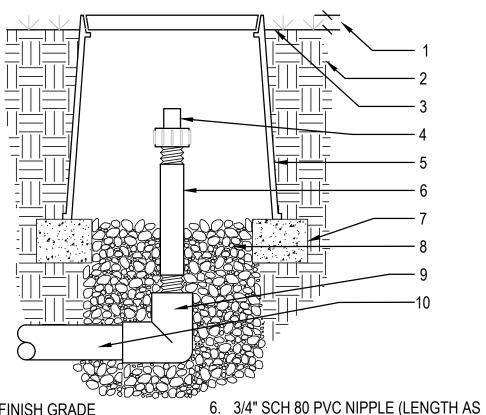

1. 1" ABOVE FINISH GRADE 2. NATIVE SOIL PER SPECIFICATIONS 3. FINISH GRADE

4. FLUSH VALVE 5. 6" ROUND PLASTIC VALVE BOX - HEAT 8. PEA GRAVEL SUMP (6" x 18") BRAND "FV" ON LID IN 1" HIGH CHARACTERS

REQUIRED) 9. PVC ELL (SxT) WITH 3/4" THREADED OUTLET 10. PVC PIPING

7. BRICK SUPPORTS (2 COMMON BRICKS


REQUIRED)

1. USE ONE FLUSH VALVE FOR EVERY 7 GPM PER ZONE.

2. LOCATE AT LOW POINTS. 3. FLUSH PRESSURE IS 2 PSI. 4. FLUSH RATE IS 0.8 GPM.

FLUSH VALVE ON PVC ELL SECTION

NOT TO SCALE

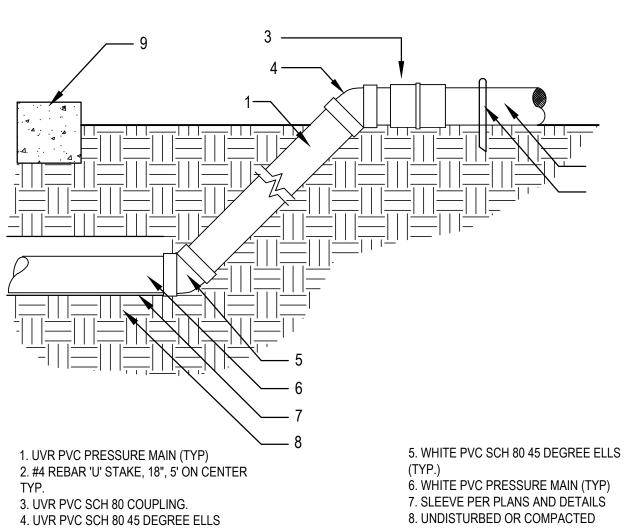

(TYP.)

SUBGRADE.

9. WALK/ DRIVEWAY PER PLANS.


ON GRADE PIPE TRANSITION

SECTION - NO SCALE

1. SUB-SURFACE DRIPLINE 2. INLINE DRIP EMITTER OUTLET 3. TIE DOWN STAKE: RAIN BIRD TDS-050 WITH BEND (TYPICAL) 4. FINISH GRADE OR SHRUB BED WITH MULCH 5. BARB X BARB FITTING RAIN BIRD XFF-ELBOW 6. 1/2" RAIN BIRD XF SERIES BLANK **TUBING** 7. QF HEADER 8. PRE-INSTALLED BARBED FITTING

1. PLACE TIE DOWN STAKES EVERY THREE FEET IN SAND, FOUR FEET IN LOAM, AND FIVE FEET IN CLAY. 2. AT FITTINGS WHERE THERE IS A CHANGE OF DIRECTION SUCH AS TEES OR ELBOWS, USE TIE-DOWN STAKES ON EACH LEG OF THE CHANGE OF DIRECTION. 3. INSERTION PLOW AND TRENCHED INSTALLATIONS DO NOT REQUIRE TIE DOWN STAKES.

DRIP TUBING INSTALLATION NOT TO SCALE

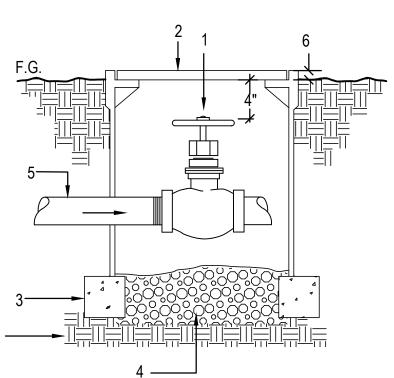

5. PVC PRESSURE MAIN (TYP)

6. AT FINISH GRADE IN TURF, 1" IN SHRUBS

7. UNDISTURBED/COMPACTED SUBGRADE


NOT TO SCALE

1. GATE VALVE OR BALL VALVE 2. ISOLATIION VALVE BOX W/EXTENSIONS AS NEEDED, HEAT BRAND COVER WITH

"DV" LETTERS 3. BRICK OR BLOCK SUPPORTS 4. PEA GRAVEL SUMP 3" DEEP


A. INSTALL AT THE LOWEST POINT OF MAIN LINE

MANUAL DRAIN VALVE

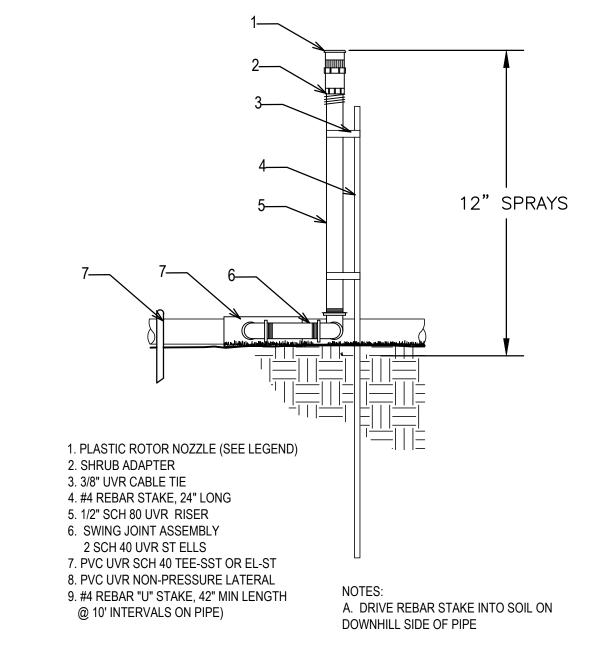

SHRUB SPRAY ON GRADE


NOT TO SCALE

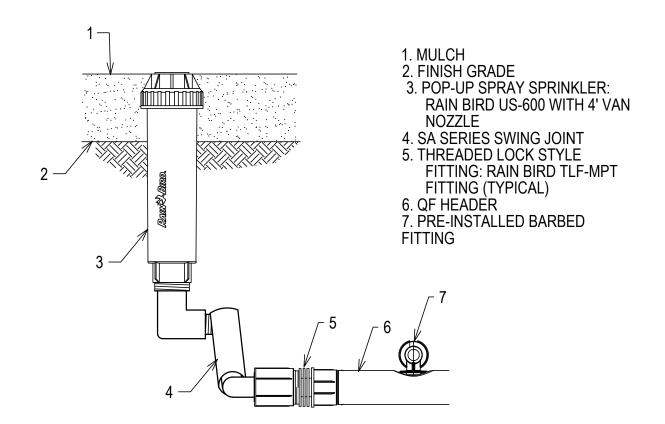

SUB-SURFACE DRIP OPERATION INDICATOR ATTACHED TO QF HEADER WITH SWING JOINT NOT TO SCALE

> CITY SUBMITTAL

CKINAW

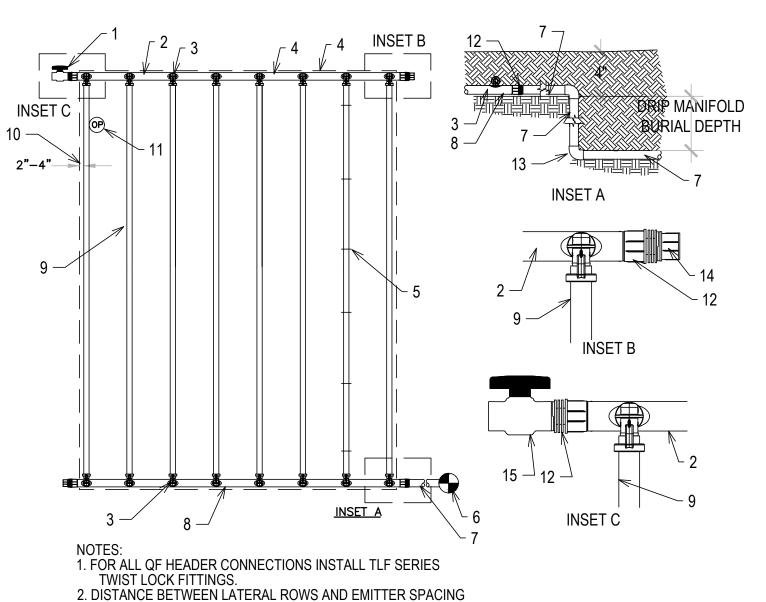

1. AUTOMATIC FLUSH VALVE PLUMBED TO FLUSH

MANIFOLD AT LOW POINT 2. QF EXHAUST HEADER 3. PRE-INSTALLED BARB FITTING

4. PERIMETER OF AREA 5. XF SERIES TIE-DOWN STAKES (TDS-050) 6. IRRIGATION CONTROL VALVE INSTALLED IN VALVE BOX

7. PVC DRIP MANIFOLD FROM CONTROL ZONE VALVE KIT 8. QF SUPPLY HEADER

9. SUB-SURFACE DRIPLINE 10. PERIMETER DRIPLINE PIPE TO BE INSTALLED 2"-4" FROM PERIMETER OF AREA 11. OPERATION INDICATOR

RAIN BIRD MODEL: OPERIND 12. TWIST LOCK FITTING: TLF-MPT 13.PVC SCH 40 ELL (TYPICAL) 14. TWIST LOCK CAP: TLF-CAP 15. PVC SCH 40 BALL VALVE

XFS-CV Dripline Maximum Lateral Lengths 12" Spacing 18" Spacing

50 397 281 573 477


60 436 309 637 529

350 248 498 416

nlet Pressure psi Nominal Flow (gph) Nominal Flow (gph) 0.6 0.9 0.6 0.9 192 136 254 215 289 205 402 337

ACCOMPANYING TABLE. SUB-SURFACE DRIPLINE END FEED LAYOUT W/ QF HEADER PLAN/ SECTION

NOT TO SCALE

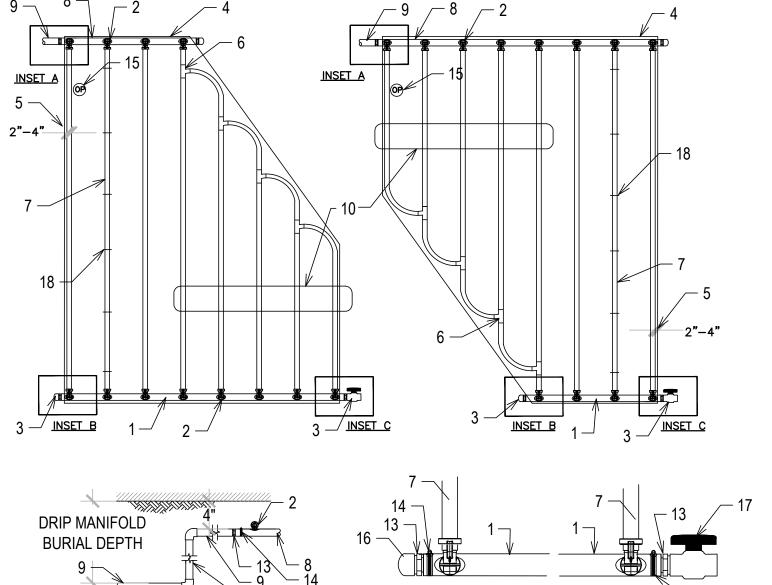

1 - QF-FLUSH HEADER 2 - PRE-INSTALLED BARB FITTING 3 - FLUSH POINT/ FLUSH VALVE

4 - PERIMETER OF AREA 5 - PERIMETER DRIPLINE PIPE TO BE INSTALLED 2"-4" FROM

PERIMETER OF AREA 6 - BARB X BARB INSERT TEE

7 - RAIN BIRD XFS SERIES DRIPLINE (TYPICAL) 8 - QF-SUPPLY HEADER 9 - PVC SUPPLY PIPE FROM RAIN BIRD CONTROL ZONE KIT 10 - TOTAL LENGTH OF SELECTED DRIPLINE SHOULD NOT

EXCEED LENGTH SHOWN IN TABLE 11 - PVC SCH 40 ELL (TYPICAL) 12 - PVC SCH 40 RISER PIPE

13 - MALE ADAPTER INSERT

14 - STAINLESS STEEL, OETIKER OR MURRAY CLAMP 15 - OPERATION INDICATOR 16 - PVC SCH 40 CAP 17 - FLUSH VALVE RAINBIRD MDCFCAP

18 - XF SERIES TIE-DOWN STAKES (TDS-050) REFER TO RAIN BIRD DRIPLINE DESIGN GUIDE FOR PROPER SPACING


A. DISTANCE BETWEEN LATERAL ROWS AND EMITTER SPACING TO BE BASED ON SOIL TYPE, PLANT MATERIALS AND CHANGES IN

ELEVATION. B. LENGTH OF LONGEST DRIPLINE LATERAL SHOULD NOT EXCEED THE MAXIMUM SPACING SHOWN IN THE ACCOMPANYING

		ateral Le	engths	
12" Sp	pacing	18" S _I	pacing	
Nominal F	low (gph)	Nominal Flow (gph)		
0.6	0.9	0.6	0.9	
192	136	254	215	
289	205	402	337	
350	248	498	416	
397	281	573	477	
436	309	637	529	
	12" Sp Nominal F 0.6 192 289 350 397	(Feet) 12" Spacing Nominal Flow (gph) 0.6 0.9 192 136 289 205 350 248 397 281	12" Spacing 18" Sport Nominal Flow (gph) Nominal Flow (gph) Nominal Flow 192 136 254 289 205 402 350 248 498 397 281 573	

SUB-SURFACE DRIP - IRREGULAR SHAPED LAYOUT QF HEADER PLAN/ SECTION

<u>INSET B</u>

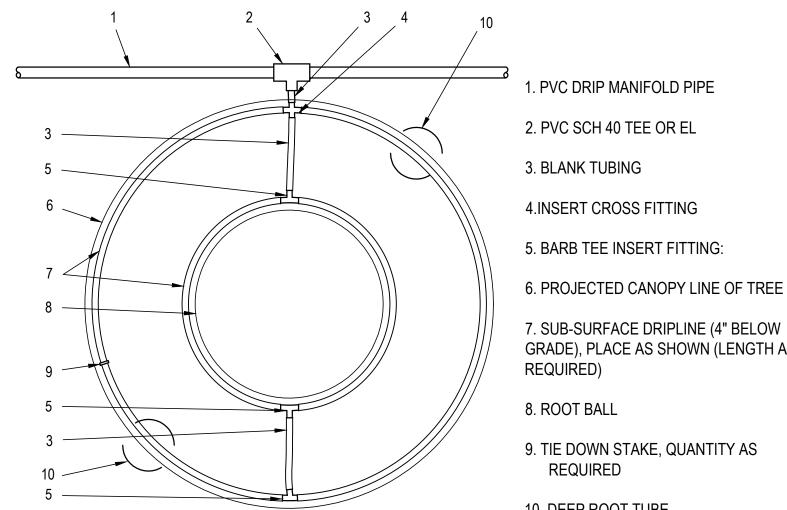

TO BE BASED ON SOIL TYPE, PLANT MATERIALS AND

3. LENGTH OF LONGEST DRIPLINE LATERAL SHOULD NOT EXCEED THE MAXIMUM SPACING SHOWN IN THE

CHANGES IN ELEVATION.

1. PVC DRIP MANIFOLD PIPE

2. PVC SCH 40 TEE OR EL

3. BLANK TUBING

7. SUB-SURFACE DRIPLINE (4" BELOW GRADE), PLACE AS SHOWN (LENGTH AS

8. ROOT BALL


9. TIE DOWN STAKE, QUANTITY AS REQUIRED

10. DEEP ROOT TUBE

1. DISTANCE BETWEEN LATERAL RINGS AND EMITTER SPACING TO BE BASED ON SOIL TYPE, AND TREE CANOPY.

2. PLACE TIE DOWN STAKES EVERY THREE FEET IN SAND, FOUR FEET IN LOAM, AND FIVE FEET IN CLAY. 3. AT FITTINGS WHERE THERE IS A CHANGE OF DIRECTION SUCH AS TEES OR ELBOWS, USE TIE-DOWN STAKES ON EACH LEG OF THE CHANGE OF DIRECTION.

SUB SURFACE DRIPLINE AROUND TREE
SECTION NOT TO SCALE

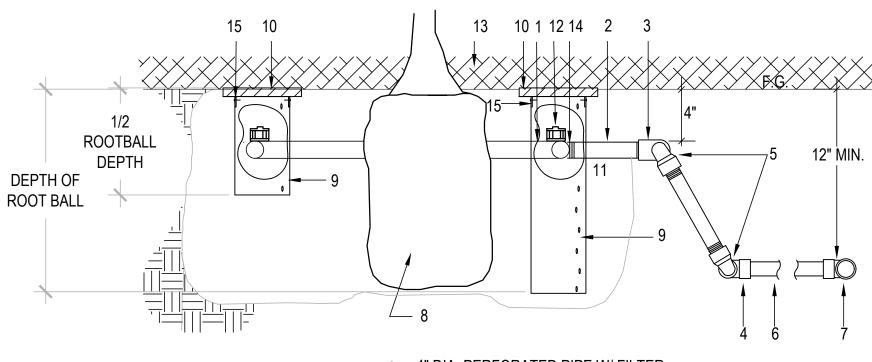

SECTION

1- INLINE DRIP-RING PE TUBE 2- BLANK PE TUBE

3- PVC SCH 40 ELL FIPT X FIPT 4- PVC SCH 40 ELL SLIP X FIPT 5- RAIN BIRD SWING JOINTS TSJ

6- PVC LATERAL EXTENSION (LENGTH AS REQ.)

7- PVC SCH 40 TEE (SSS) OR ELL (SS) ON PVC LATERAL 8- TREE ROOT BALL.

9- 4" DIA. PERFORATED PIPE W/ FILTER FABRIC AERATION TUBE FOR TREE.

10- NDS 4" FLAT ROUND GRATE OVER TUBE, GREEN COLOR


11- PENETRATE AERATION TUBE FOR INSERTION OF BUBBLER (AS DIRECTED BY LANDSCAPE

ARCHITECT) 12- XERI-BUBBLER BARBED EMITTER

13- MULCH 14- COMPRESSION TEE

15- 1/2" x #14 STAINLESS STEEL SCREW

DEEP ROOT TUBE (BELOW GRADE) NOT TO SCALE

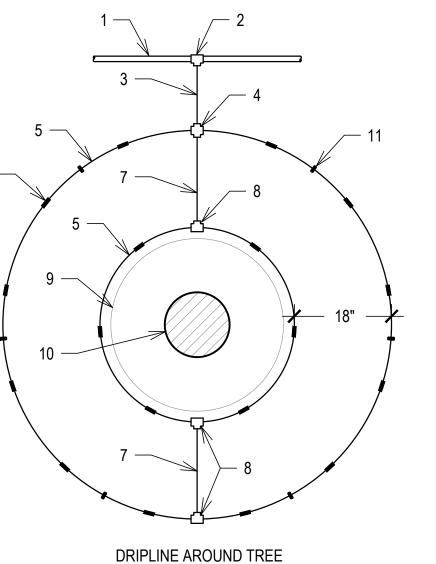

DRIPLINE ASSEMBLY OR DRIPLINE LATERAL 2. PVC OR DRIPLINE INSERT FITTING

1. ON GRADE PVC LATERAL FROM

3. BLANK DRIPLINE TUBING (LENGTH AS NECESSARY)

4. DRIPLINE INSERT CROSS FITTING 5. ON SURFACE DRIPLINE TUBING

6. DRIP EMITTER, SPACING PER IRRIGATION SCHEDULE 7. BLANK DRIPLINE TUBING

8. DRIPLINE INSERT TEE FITTING 9. EDGE OF ROOTBALL

10. TREE TRUNK

11. TIE-DOWN STAKE (MAX SPACING 36" ALONG DRIPLINE AND AT ALL BRANCHES OF FITTINGS)

ON-GRADE DRIPLINE AROUND TREE

CONNECTED TO LATERAL

NOT TO SCALE

CKINAW

CITY SUBMITTAL

ATER EFFICIENT LANDSCAPE WORKSHEET naw Hotel - City of Placerville, CA 2/29/2024	MWELO LANDSCAPE DOCUMENTATION PACKAGE	CERTIFICATE OF COMPLETION (SHALL BE SUBMITTED TO THE CITY ONCE CONSTRUCTION HAS BEEN		_ =<
56.96		COMPLETED)	THE LANDSCAPE PROJECT HAS BEEN INSTALLED PER THE APPROVED LANDSCAPE	
TION A: HYDROZONE INFORMATION TABLE	THE LANDSCAPE DOCUMENT PACKAGE SHALL INCLUDE THE FOLLOWING SIX ELEMENTS: 1. PROJECT INFORMATION	THE FOLLOWING SHALL BE SUBMITTED TO THE CITY, THE WATER PURVEYOR, AND THE OWNER UPON COMPLETION OF CONSTRUCTION:	DOCUMENTATION PACKAGE WATER EFFICIENT LANDSCAPE WORKSHEET	
REGULAR LANDSCAPE AREAS A B C D E F G H I J	1.A. DATE: SEE TITLEBLOCK	1. PROJECT INFORMATION		
Plant Irrigation ETAF Hydro Some Area ETAF x HA ETWU Londonno L	1.B. PROJECT APPLICANT: SEE TITLE SHEET	1.A. DATE	JAMES P. NERI NERI LANDSCAPE ARCHITECTURE	
Ave. (PF) Method IE (PF/IE) Zone Area (HA) (sf) Landscape Area	1.C. PROJECT ADDRESS (IF AVAILABLE, PARCEL/ LOT NUMBERS): SEE CIVIL PLANS1.D. TOTAL LANDSCAPE AREA (SF): SEE 'CALIFORNIA WATER EFFICIENT LANDSCAPE	1.B. PROJECT NAME 1.C. PROJECT APPLICANT NAME, TELEPHONE, AND MAILING ADDRESS	LICENSED LANDSCAPE ARCHITECT, RLA#3321	
Low Water Ground cover (ROW	WORKSHEET' THIS SHEET	1.D. PROJECT ADDRESS (IF AVAILABLE, PARCEL/ LOT NUMBERS)		
4, 31 & 33 & on-site) 0.2 DRIP 0.81 0.25 5,860 1465.00 51,737 16.8% Low water use trees (north	1.E. PROJECT TYPE (NEW, REHABILITATED, PUBLIC, PRIVATE, CEMETERY, ETC.): NEW1.E.A. WATER SUPPLY TYPE: POTABLE	1.E. PROPERTY OWNER NAME, TELEPHONE, AND MAILING ADDRESS	LANDSCAPE DESIGN COMPLIANCE STATEMENT	
2,5,32 side,sun) 0.2 DRIP 0.81 0.25 184 46.00 1,624 0.5% Low Water Use shrubs (shade	1.F. WATER PURVEYOR: CITY OF PLACERVILLE	2. CERTIFICATION BY EITHER THE SIGNER OF THE LANDSCAPE DESIGN PLAN, THE SIGNER OF	I HAVE COMPLIED WITH THE CRITERIA OF THE ORDINANCE AND APPLIED THEM FOR	
26 & 30 areas) 0.2 DRIP 0.81 0.25 1,189 297.25 10,497 3.4% Low Water Use shrubs & 0.2 DRIP 0.81 0.25 1,189 297.25 10,497 3.4%	1.G. CHECKLIST OF ALL DOCUMENTS IN THE LANDSCAPE DOCUMENTATION PACKAGE: THIS LIST	THE IRRIGATION DESIGN PLAN, OR THE LICENSED LANDSCAPE CONTRACTOR THAT THE LANDSCAPE PROJECT HAS BEEN INSTALLED PER THE APPROVED LANDSCAPE	THE EFFICIENT USE OF WATER IN THE LANDSCAPE DESIGN PLAN	
7 groundcover (sun) 0.2 DRIP 0.81 0.25 1,154 288.50 10,188 3.3% Low Water Use trees (west 13 & 16 parking area, sun) 0.2 DRIP 0.81 0.25 198 49.50 1,748 0.6%	1.H. PROJECT CONTACTS TO INCLUDE CONTACT INFORMATION FOR THE PROJECT	DOCUMENTATION PACKAGE WATER EFFICIENT LANDSCAPE WORKSHEET:	1 sensor X/a	
13 & 16 parking area, sun) 0.2 DRIP 0.81 0.25 198 49.50 1,748 0.6% 9 Low Water Use shrubs (planter) 0.2 DRIP 0.81 0.25 171 42.75 1,510 0.5%	APPLICANT AND PROPERTY OWNER: SEE TITLE SHEET 1.I. APPLICANT (REPRESENTATIVE'S) SIGNATURE AND DATE WITH COMPLIANCE STATEMENT:	2.A. WHERE THERE HAVE BEEN SIGNIFICANT CHANGES MADE IN THE FIELD DURING CONSTRUCTION, THESE 'AS-BUILT' OR RECORD DRAWINGS SHALL BE INCLUDED WITH	2/29/24	-
High Water use Trees (south 27 & 28 side, sun) 0.7 DRIP 0.81 0.86 78 67.08 2,369 0.2%	SEE THIS SHEET	THE CERTIFICATION 2.B. A DIAGRAM OF THE IRRIGATION PLAN SHOWING HYDROZONES SHALL BE KEPT WITH THE	JAMES P. NERI NERI LANDSCAPE ARCHITECTURE	
Low Water use shrubs (south side, sun) 0.2 DRIP 0.81 0.25 688 172.00 6,074 2.0%	2. WATER EFFICIENT LANDSCAPE WORKSHEET: SEE THIS SHEET	IRRIGATION CONTROLLER FOR SUBSEQUENT MANAGEMENT PURPOSES	LICENSED LANDSCAPE ARCHITECT, RLA#3321	
Low Water Use shrubs & 0.2 SPRAY 0.75 0.27 2,270 612.90 21,645 6.5%	2.A. HYDROZONE INFORMATION TABLE	3. IRRIGATION SCHEDULING PARAMETERS USED TO SET THE CONTROLLER		
Low Water Use groundcover (slope, sun - temporary	2.B. WATER BUDGET CALCULATIONS AND A MAXIMUM ARRUSED MATER ALL COMMANCE (MANA)	4. LANDSCAPE AN IRRIGATION MAINTENANCE SCHEDULE		
2,38 & 39 irrigation) 0.2 SPRAY 0.75 0.27 13,482 3640.14 128,552 38.5%	2.B.A. MAXIMUM APPLIED WATER ALLOWANCE (MAWA) 2.B.B. ESTIMATED TOTAL WATER USE (ETWU)	5. IRRIGATION AUDIT REPORT (ALL IRRIGATION AUDITS SHALL BE CONDUCTED BY A LOCAL		
16 (slope,sun - temporary irrigation) 0.2 DRIP 0.81 0.25 84 21.00 742 0.2% High Water Use slope trees		AGENCY LANDSCAPE IRRIGATION AUDITOR OR A THIRD PARTY CERTIFIED LANDSCAPE IRRIGATION AUDITOR. LANDSCAPE AUDITS SHALL NOT BE CONDUCTED BY THE PERSON WHO		K
High Vivater Use slope trees 3 & 25 (sun) 0.7 DRIP 0.81 0.86 126 108.36 3,827 0.4% Low Water Use Groundcover	3. SOIL MANAGEMENT REPORT: SEE GEOTECHNICAL REPORT4. LANDSCAPE DESIGN PLAN: SEE ATTACHED	DESIGNED THE LANDSCAPE OR INSTALLED THE LANDSCAPE)		<u>-</u>
4 & 29 (sun, south side) 0.2 DRIP 0.81 0.25 1,216 304.00 10,736 3.5%	4. LANDSCAPE DESIGN PLAN: SEE ATTACHED 5. IRRIGATION DESIGN PLAN: SEE HYDROZONE PLAN	6. SOIL ANALYSIS REPORT IF NOT SUBMITTED WITH LANDSCAPE DOCUMENTATION PACKAGE,	42///	
High Water Use Trees (sun, 5 & 28 south parking area) 0.7 DRIP 0.81 0.86 56 48.16 1,701 0.2%	6. GRADING DESIGN PLAN: SEE CIVIL PLANS	AND DOCUMENTATION VERIFYING IMPLEMENTATION OF SOIL REPORT RECOMMENDATIONS		
Low Water Use (sun, east 3,34 & 36 parking area) 0.2 drip 0.81 0.25 4,337 1084.25 38,291 12.4% 35 High Water use Trees (sun) 0.7 drip 0.81 0.86 112 96.32 3,402 0.3%	I AGREE TO COMPLY WITH THE REQUIREMENTS OF THE WATER EFFICIENT		40 & 41	
Low Water use Trees (slope,	LANDSCAPE ORDINANCE AND SUBMIT A COMPLETE LANDSCAPE DOCUMENTATION PACKAGE			
Low Water Use groundcover	I AUNAUL		42	
43 Low Water Use vines (sun) 0.2 MP 0.75 0.27 110 29.70 1,049 0.3%	_ Jano Keni			
44 Spa 1.0 - 1.0 1.00 100 100.00 3,532 0.3% Total 16.2 TOTALS 34,984 9434.16 333,171 100%	JAMES P. NERI	33	40 & 41	NDSCA
TOTALS 34,984 9434.16 333,171 100%	NERI LANDSCAPE ARCHITECTURE LICENSED LANDSCAPE ARCHITECT, RLA#3321		BIC STORY OF TO THE PARTY OF TH	
		32	10 TC 2213.76 F 9 2 2 2 1 3 7 6 F 9 2 2 2 2 1 3 7 6 F 9 2 2 2 2 1 3 7 6 F 9 2 2 2 2 3 7 6 F 9 2 2 2 2 3 7 6 F 9 2 2 2 2 3 7 6 F 9 2 2 2 2 3 7 6 F 9 2 2 2 2 3 7 6 F 9 2 2 2 3 7 6 F 9 2 2 2 3 7 6 F 9 2 2 2 3 7 6 F 9 2 2 2 3 7 6 F 9 2 2 3 2 3 7 6 F 9 2 2 3 2 3 7 6 F 9 2 2 3 2 3 7 6 F 9 2 2 3 2 3 7 6 F 9 2 2 3 2 3 2 3 2 3 2 3 2 3 2 3 2 3 2 3	-
TOTALS 0.00 0.00 0%			S 2215 2 2 2 2 2 2 2 2 2 2 2 2 2 2 2 2 2	
Estimated Water Use (ETWU) Total 333,171 Maximum Water Allowance (MAWA) 518,896			37	
Irrigation Efficiency (IE) Average** 1.0		2215 82 16 32	2216.43 to 216.43 to 216.4	
TION R1: MAXIMUM ADDI IED WATER ALLOWANCE (MANA)		22169 TG 221769 TG	2218 C	((
TION B1: MAXIMUM APPLIED WATER ALLOWANCE (MAWA) A = (Eto)(0.62) [(ETAF x (LA+SLA)] + [(1-ETAF) x SLA)]		2216.16 50	35	
56.96 ETo		5 35		ā
x 0.62 Conv. Factor	4	32		(
x 34,984 LA *Per City of Placerville Standards + 0.00 SLA HYDROZONE CATEGORY PF	DOAD	0. The state of th	42 1/4/18/6/2	(L
MAWA = 518,896 gal/yr Very Low Water Use 0.0-0.1 Low Water Use 0.1-0.3	5 KO 5			l (
Moderate Water Use 0.4-0.6 LAR LANDSCAPE AREAS TOTALS High Water Use 0.7-1.0	THE ROLLAGOR	44	2 2 2 2 2 2 2 2 2 2 2 2 2 2 2 2 2 2 2	(
ETAF x Area 9,434 B Area 34,984 A IRRIGATION METHOD IE	JAN	34 & 4	3 20,21,22,	(-
ge ETAF 0.27 B / A Pools/Spas 1.00 Drip/Subsurface 0.81		30	38 & 39	-
ANDSCAPE AREAS TOTALS Overhead Spray 7.75 TAF x Area 7.75 TOTALS 0.01	103	29 28 3 43		
Area 9,434 B+D Area 34,984 A+C ide ETAF 0.27 (B+D) / (A+C)	26	134 128 1321 1321 1321 1321 1321 1321 1321	PROPERTYLINE	
5.21 (B·D)7 (A·G)	3 6	29 28 29	23	
	300 mm 139 6 0 1/1/2/ 10 13834 139	104		
	141 125 2 128 141 141 141 141 141 141 141 141 141 14	The state of the s		
13 ELCRING		25	20,21,22,	
	1402	24	38 & 39	
13	8 27 0	23		
	27	25		
	è è	24 43		
10				
13	OF ON			
12	10° 43	38 839		
12	10 43	38 839		
12	25 10 10 10 10 10 10	38 & 39		
12 13 13 13	10 10 43 25 10 10 10 10 10 10 10 10 10 10 10 10 10			
12	8 10 11	23	CERTIFY LANGE.	
12	25 10 10 15 25 10 15 20	23	PERTY LAWS	
12		23 PROPERTY LINE	TERT LINE	
12	16	23	TIME THE	
12 13 14 13	17,18 & 19	23 21,22, 23 PROPERTY LINE		•
12 13 13 13 14 13 13 13 13 13 13 13 13 13 13 13 13 13	16	23 21,22, 23 PROPERTY LINE	DERIFFERENCE OF THE PARTY OF TH	•

WATERING SCHEDULE (ESTABLISHMENT PERIOD - 7 DAYS A WEEK)

MACKINAW IRRIGATION RUN TIME SCI	HEDULE - ESTABLIS	HIVIENT PEK	עטו										2	_		_	
CONTROLLER					Jan	Feb	Mar	Apr	May	Jun	Jul	Aug	Sep	Oct	Nov	Dec	TOTAL ETO/ YEAR
Α				ETO/ MONTH (IN):	2.5	2.9	4.1	5.5	6.2	6.4	7.6	6.8	5.2	4.4	2.9	2.4	56.96
<i>-</i>				ETO/DAY (IN):	0.08	0.10	0.13	0.18	0.20	0.21	0.25	0.22	0.17	0.14	0.10	0.08	
	T	I	# OF DAVC	<u> </u>													T
\/A1\/F		IRRIG EFF	# OF DAYS	PRECIP RATE													
VALVE NUMBER ZONE DESCRIPTION	PLANT FACTOR (PF)		TO IRRIGATE	(IN/HR)	Jan	Feb	Mar	Anr	May	lun	Jul	Aug	Sep	Oct	Nov	Dec	
LOW WATER USE PLANTS,	PLANT FACTOR (PF)	(12)	INNIGATE	(IIV/TIK)	Jaii	reb	IVIdI	Apr	iviay	Jun	Jui	Aug	Sep	OCI	INOV	Dec	
1,3,4,31,33 DRIP IRRG	0.2	0.81	7	0.96	1	2	2	3	3	3	4	3	3	2	2	1	MIN/ DAY / ZONE
1,3,4,31,33 DINI MING	0.2	. 0.01	# OF ZONES		5	10	10	15	15	15	20	15	15	10	10	5	TOTAL MIN / DAY
LOW WATER USE PLANTS,			# OT ZOIVES	, ,		10	10	10	13	10	20	13	13	10	10		TOTALIVIIIV / DAT
2,5,32 DRIP IRRG	0.2	0.81	7	0.96	1	2	2	3	3	3	4	3	3	2	2	1	MIN/ DAY / ZONE
2,3,32	0.2	., 0.01	# OF ZONES		3	6	6	9	9	9	12	9	9	6	6	3	TOTAL MIN / DAY
LOW WATER USE SHRUBS																	
6,26,30 (SHADE AREAS)	0.2	0.81	7	0.96	1	2	2	3	3	3	4	3	3	2	2	1	MIN/ DAY / ZONE
			# OF ZONES		3	6	6	9	9	9	12	9	9	6	6	3	TOTAL MIN / DAY
7,9,11,12,1 LOW WATER USE PLANTS,																	
4,24,29, DRIP IRRG	0.2	0.81	7	0.96	1	2	2	3	3	3	4	3	3	2	2	1	MIN/ DAY / ZONE
			# OF ZONES	7	7	14	14	21	21	21	28	21	21	14	14	7	TOTAL MIN / DAY
8,13,16,37, LOW WATER USE TREES, DRIP																	
42 IRRG	0.2	0.81	7	0.96	1	2	2	3	3	3	4	3	3	2	2	1	MIN/ DAY / ZONE
			# OF ZONES	5	5	10	10	15	15	15	20	15	15	10	10	5	TOTAL MIN / DAY
10,23,25,26 HIGH WATER USE TREES, DRIP																	
,27,28,35 IRRG	0.7	0.81	7	0.96	4	5	7	10	11	11	14	12	9	8	5	4	MIN/ DAY / ZONE
		_	# OF ZONES	7	28	35	49	70	77	77	98	84	63	56	35	28	TOTAL MIN / DAY
15,17,18,19																	
,20,21,22,3 LOW WATER USE																	
8 & 39 GROUNDCOVER, SPRAY IRRG	0.2	0.75		0.85	2	2	2	3	4	4	5	4	3	3	2	2	MIN/ DAY / ZONE
			# OF ZONES	9	18	18	18	27	36	36	45	36	27	27	18	18	TOTAL MIN / DAY
LOW WATER USE PLANTS,															_		
34,36,41,42 DRIP IRRG	0.2	•		0.96	1	2	2	3	3	3	4	3	3	2	2	1	MIN/ DAY / ZONE
			# OF ZONES	4	4	8	8	12	12	12	16	12	12	8	8	4	TOTAL MIN / DAY
LOW WATER USEVINES,		<u> </u>			-	-	•	•			_		-	-	•	-	NAIN / DAY /
43 SPRAY IRRG	0.2	•		0.85	2	2	2	3	4	4	5	4	3	3	2	2	MIN/ DAY / ZONE
			# OF ZONES	1	2	2	2	3	4	4	5	4	3	3	2	2	TOTAL MIN / DAY
			TOTAL # 65		Jan	Feb	Mar	Apr	May	Jun	Jul	Aug	Sep	Oct	Nov	Dec	-
TOTAL # OF						100	122	101	100	100	250	205	474	140	100	75	TOTAL BAIN / DAY
			ZONES	44	75 1.2	109	123	181	198	198	256	205	174	140	109	75 1.2	TOTAL HDS / DAY
				IAL ADULGES SENTER	1.3	1.8	2.1	3.0	3.3	3.3	4.3	3.4	2.9	2.3	1.8	1.3	TOTAL HRS / DAY
			SEASON	NAL ADJUSTMENT %	30%	42%	49%	70%	77%	77 %	100%	79%	67%	53%	42%	30%	1

*Disclaimer: Run times shown are based on historical weather, average plant, and manufacturer's irrigation test data and are intended for use as an initial guide in irrigation controller programming.

The irrigation programmer shall adjust all irrigation run times shown according to observed plant health, soil moisture, and site microclimates. Note: Seasonal Adjustments are based on July @ 100%.

WATERING SCHEDULE (POST ESTABLISHMENT PERIOD - 3 DAYS A WEEK)

				CEACON	AL ADJUSTMENT %	33%	42%	53%	70%	79%	84%	100%	89%	66%	56%	42%	33%	
						3.2	4.0	5.1	6.7	7.6	8.1	9.6	8.5	6.3	5.4	4.0	3.2	TOTAL HRS / DAY
ZONES 44						191	239	307	403	454	488	577	512	379	321	239	191	TOTAL MIN/ DAY
				TOTAL # OF		Juil	1 00	MIGI	Abi	iviuy	Juil	J41	, rug	Jep	366	,,,,,	Dec	1
				# OF ZUNES	1	Jan	Feb	Mar	Apr	May	Jun	Jul	Aug	Sep	Oct	Nov	Dec	TOTAL WIIN / DAY
43	SPRAY IRRG	0.2		# OF ZONES	0.85	4	4	6	8	9	9	11 11	10 10	7	6	4	4	MIN/ DAY / ZONE TOTAL MIN / DAY
	LOW WATER USEVINES,						-	-		_	_			_	_			/ = / =
				# OF ZONES	4	12	16	20	24	28	32	36	32	24	20	16	12	TOTAL MIN / DAY
34,36,41,42	LOW WATER USE PLANTS, DRIP IRRG	0.2	0.81	3	0.96	3	4	5	6	7	8	9	8	6	5	4	3	MIN/ DAY / ZONE
				# OF ZONES	9	36	36	54	72	81	81	99	90	63	54	36	36	TOTAL MIN / DAY
	LOW WATER USE GROUNDCOVER ,SPRAY IRRG	0.2			0.85	4	4	6	8	9	9	11	10	7	6	4	4	MIN/ DAY / ZONE
15,17,18,19				# OF ZOINES	7	70	2T	114	TOT	1/3	102	224	130	T-+/	120		70	TOTAL WIIN / DAT
,21,20,33	IMMO	0.7		# OF ZONES		70	91	112	161	175	182	224	196	147	126	91	70	TOTAL MIN / DAY
10,23,25,26 ,27,28,35	HIGH WATER USE TREES, DRIP	0.7	0.81	2	0.96	10	13	16	23	25	26	32	28	21	18	13	10	MIN/ DAY / ZONE
40.00.00				# OF ZONES	5	15	20	25	30	35	40	45	40	30	25	20	15	TOTAL MIN / DAY
12 12	IRRG	0.2	0.81	3	0.96	3	4	5	6	7	8	9	8	6	5	4	3	MIN/ DAY / ZONE
3,13,16,37,	LOW WATER USE TREES, DRIP			# OF ZUIVES	/	21	20	35	42	49	56	63	56	42	35	28	21	TOTAL MIN / DAY
4,24,29,	DRIP IRRG	0.2		# OF ZONES	0.96	3	4 28	5	6	7	8	9	8	6 42	5	4	3	MIN/ DAY / ZONI
7,9,11,12,1	LOW WATER USE PLANTS,			5. 251125	3					<u> </u>	<u>~ 1'</u>	/	<u> </u>	10				
0,20,30	(STIADE AINEAS)	0.2		# OF ZONES		9	12	15	18	21	24	27	24	18	15	12	9	TOTAL MIN / DAY
5,26,30	LOW WATER USE SHRUBS (SHADE AREAS)	0.2	0.81	2	0.96	3	4	5	6	7	8	9	8	6	5	4	3	MIN/ DAY / ZON
				# OF ZONES		9	12	15	18	21	24	27	24	18	15	12	9	TOTAL MIN / DAY
2,5,32	LOW WATER USE PLANTS, DRIP IRRG	0.2	0.81	3	0.96	3	4	5	6	7	8	9	8	6	5	4	3	MIN/ DAY / ZONE
				# OF ZONES	5	15	20	25	30	35	40	45	40	30	25	20	15	TOTAL MIN / DAY
1,3,4,31,33	DRIP IRRG	0.2	0.81	3	0.96	3	4	5	6	7	8	9	8	6	5	4	3	MIN/ DAY / ZONE
NOIVIDEN	LOW WATER USE PLANTS,	PLANT PACTOR (PT)	(IL)	IKKIGATL	(HV/THV)	Jan	reb	IVIAI	Арі	iviay	Juli	Jui	Aug	Sep	Oct	NOV	Dec	
VALVE NUMBER	ZONE DESCRIPTION	PLANT FACTOR (PF)	IRRIG EFF	TO IRRIGATE	PRECIP RATE (IN/HR)	Jan	Feb	Mar	Apr	May	Jun	Jul	Aug	Sep	Oct	Nov	Dec	
				# OF DAYS														
					ETO/DAT (IIV).	0.08	0.10	0.13	0.10	0.20	0.21	0.25	0.22	0.17	0.14	0.10	0.08	
	Α				ETO/ MONTH (IN): ETO/DAY (IN):	2.5 0.08	2.9 0.10	4.1 0.13	5.5 0.18	6.2 0.20	6.4 0.21	7.6 0.25	6.8 0.22	5.2 0.17	4.4 0.14	2.9 0.10	2.4 0.08	56.96
	CONTROLLER					Jan	Feb	Mar	Apr	May	Jun	Jul	Aug	Sep	Oct	Nov	Dec	TOTAL ETO/ YEAR

*Disclaimer: Run times shown are based on historical weather, average plant, and manufacturer's irrigation test data and are intended for use as an initial guide in irrigation controller programming.

The irrigation programmer shall adjust all irrigation run times shown according to observed plant health, soil moisture, and site microclimates. Note: Seasonal Adjustments are based on July @ 100%.

I HAVE COMPLIED WITH THE CRITERIA OF THE REGULATIONS AND APPLIED THEM FOR THE EFFICIENT USE OF WATER IN THE IRRIGATION DESIGN PLAN.


Jano New

JAMES P. NERI NERI LANDSCAPE ARCHITECTURE LICENSED LANDSCAPE ARCHITECT, RLA#3321

> Drawn -Checked - JPN

Draw Chec

NERI LANDSCAPE

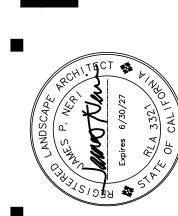


MACKINAW HOTEL


3001 Jacquier Road
Placewille, CA, 95667

CITY SUBMITTAL 9/18/2025

IRRIGATION RUN TIME

L2.7

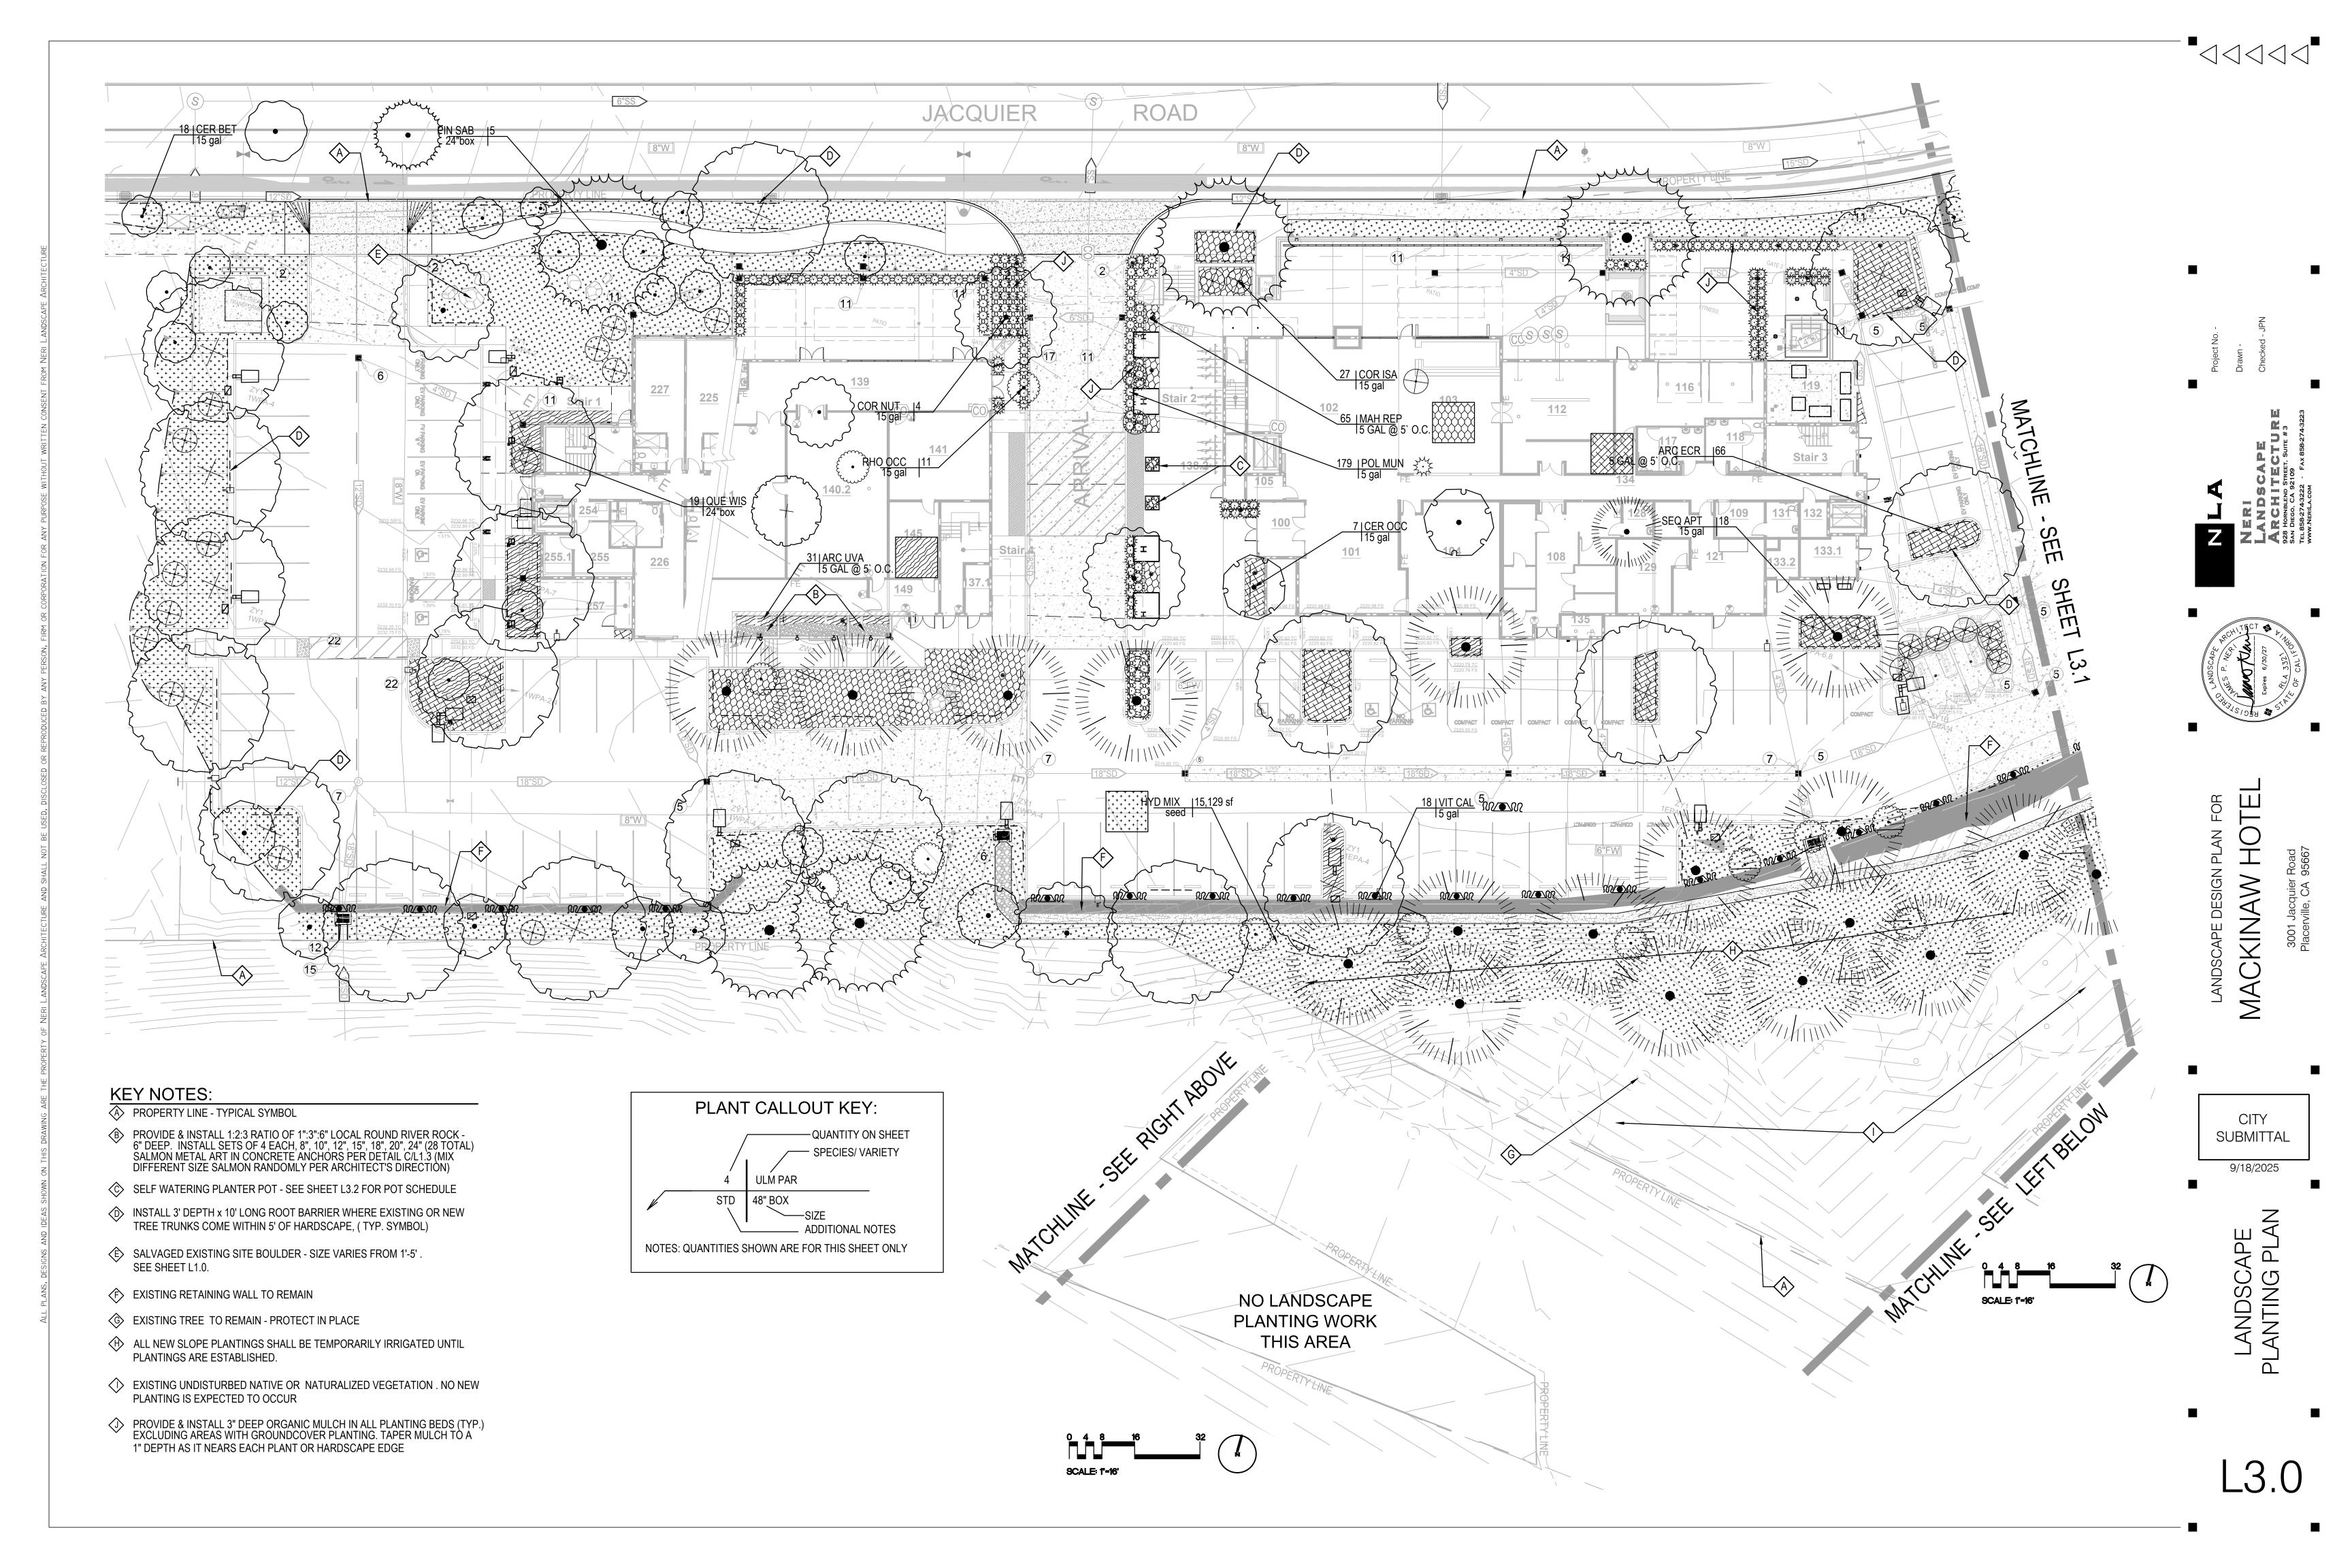

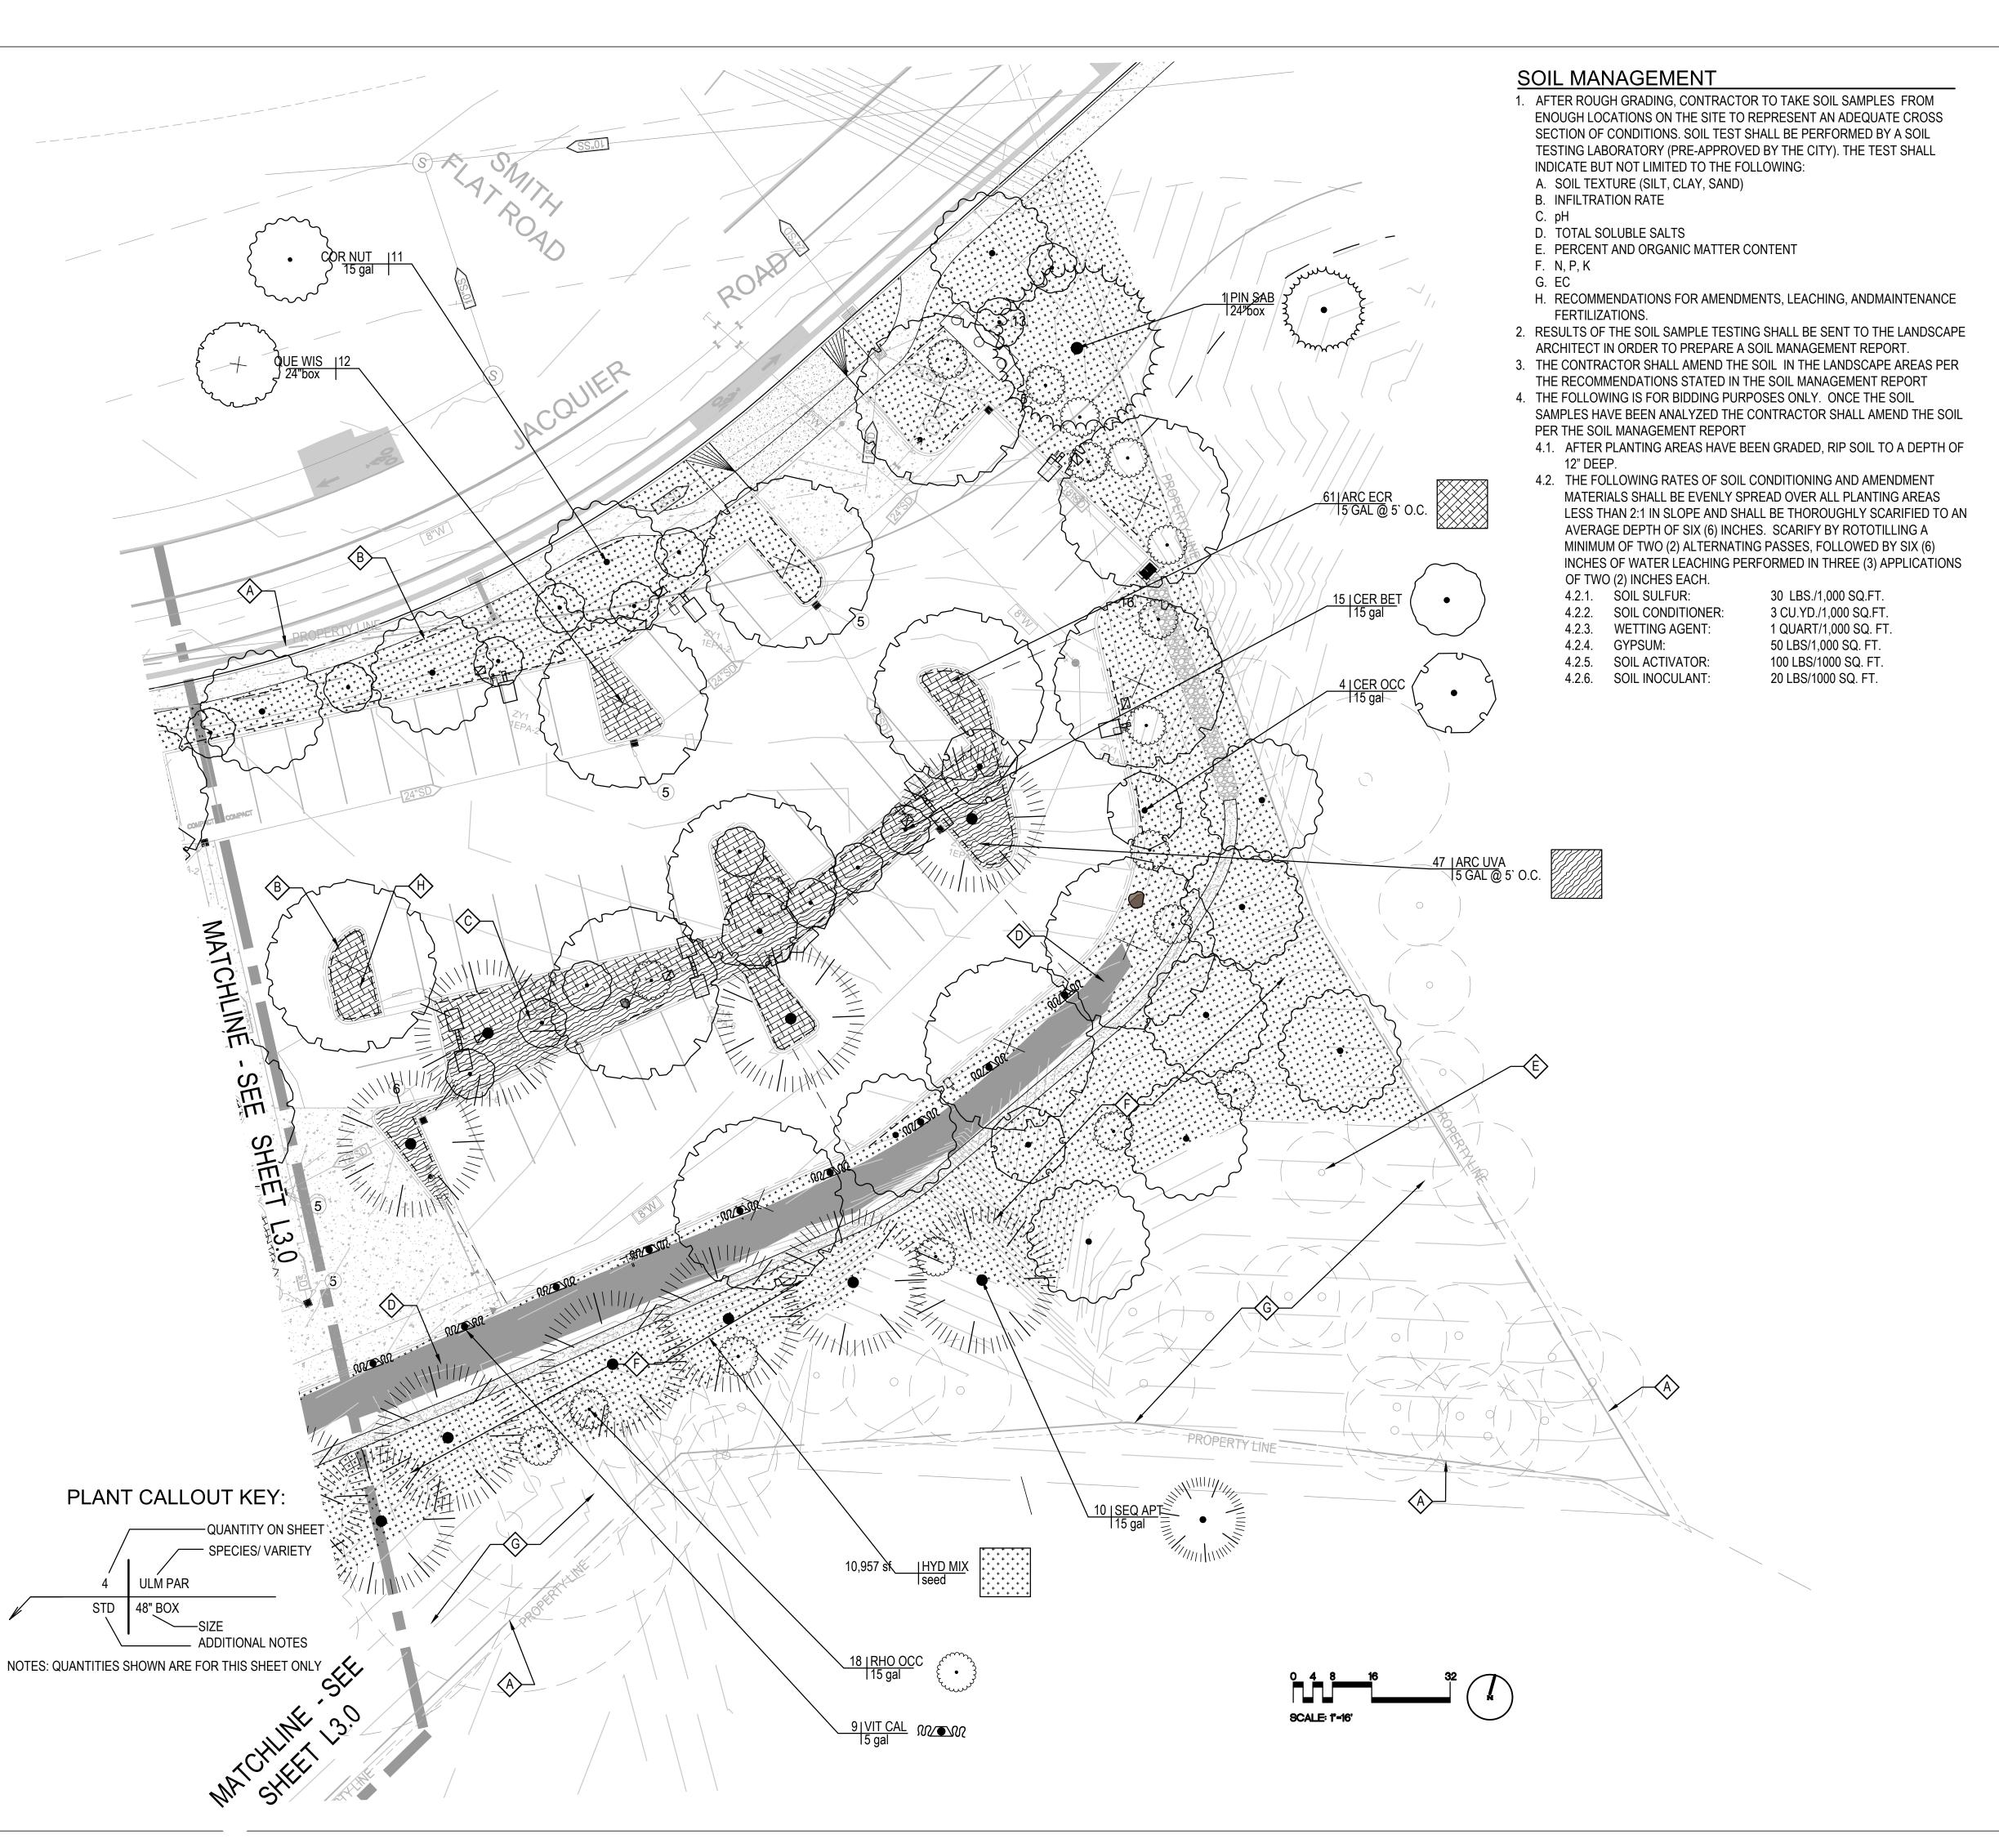

KEY NOTES:

- A PROPERTY LINE TYPICAL SYMBOL
- (B) INSTALL 3' DEPTH x 10' LONG ROOT BARRIER WHERE EXISTING OR NEW TREE TRUNKS COME WITHIN 5' OF HARDSCAPE, (TYP. SYMBOL)
- SALVAGED EXISTING SITE BOULDER SIZE VARIES FROM 1'-5' SEE SHEET L1.0.
- (D) EXISTING RETAINING WALL TO REMAIN
- **(È)** EXISTING TREE TO REMAIN PROTECT IN PLACE
- ALL NEW SLOPE PLANTINGS SHALL BE TEMPORARILY IRRIGATED UNTIL PLANTINGS ARE ESTABLISHED.
- © EXISTING UNDISTURBED NATIVE OR NATURALIZED VEGETATION . NO NEW PLANTING IS EXPECTED TO OCCUR
- PROVIDE & INSTALL 3" DEEP ORGANIC MULCH IN ALL PLANTING BEDS (TYP.) EXCLUDING AREAS WITH GROUNDCOVER PLANTING. TAPER MULCH TO A 1" DEPTH AS IT NEARS EACH PLANT OR HARDSCAPE EDGE


GENERAL NOTES

- 1. PROVIDE POSITIVE SURFACE DRAINAGE (2% GRADE IN PLANTING AREAS) AWAY FROM STRUCTURES AND TERMINATING IN AN APPROVED DRAINAGE SYSTEM.
- 2. THE CONTRACTOR SHALL CONTACT THE LANDSCAPE ARCHITECT PRIOR TO BEGINNING LANDSCAPE WORK TO REVIEW THE FINAL PROJECT UTILITY LOCATIONS AND ADJUST PLANTING TO FULLY SCREEN ALL UTILITIES FROM VIEW.
- 3. SEE SPECIFICATIONS FOR ITEMS NOT COVERED ON THESE PLANS.
- 4. THE CONTRACTOR SHALL RECONCILE THE CALLOUT QUANTITIES WITH THE GRAPHIC QUANTITIES AND SHALL PROVIDE PLANTS EQUAL TO THE GRAPHIC QUANTITIES SHOWN ON THE PLANS.
- 5. ALL PLANT MATERIAL IS TO BE SUPPLIED AND INSTALLED BY THE LANDSCAPE CONTRACTOR.
- 6. THE LANDSCAPE ARCHITECT SHALL RETAIN THE OPTION TO TAG BOXED TREE MATERIAL AT A WHOLESALE NURSERY OF THEIR CHOICE AFTER THE BID HAS BEEN AWARDED.
- 7. PLANTS SHALL BE SUBJECT TO INSPECTION AND APPROVAL OR REJECTION BY THE LANDSCAPE ARCHITECT UPON DELIVERY TO THE SITE.
- 8. PLANT MATERIAL LOCATIONS ON THE PLANTING PLAN ARE APPROXIMATE AND SHALL BE ADJUSTED AS DIRECTED BY THE LANDSCAPE ARCHITECT.
- 9. ALL GROUNDCOVER PLANTS SHALL BE FULLY ROOTED PLANT MATERIAL IN FLATS, PLUGS OR POTS.
- 10. BUDS AND BLOOMS ON ALL PLANTS MUST BE PROTECTED AT ALL TIMES, INCLUDING TRANSPORTATION AND INSTALLATION.
- 11. STAKE AND/OR GUY ALL TREES AS DIRECTED IN THE LEGEND AND PER THE PLANTING
- DETAILS.
- 12. TREES AND SHRUBS SHALL BE SHAPED AND PRUNED DURING THE MAINTENANCE PERIOD ONLY AS DIRECTED BY THE LANDSCAPE ARCHITECT.
- 13. THE CONTRACTOR SHALL GUARANTEE SHRUBS, GROUNDCOVERS AND PERENNIALS FOR A PERIOD OF THREE MONTHS AND TREES FOR ONE YEAR FROM DATE OF FINAL ACCEPTANCE.
- 14. ALL PLANTING BACKFILL IN PLANTING AREAS SHALL BE AMENDED WITH A THOROUGHLY BLENDED MIXTURE OF SOIL AND SOIL ACTIVATOR 'GRO-POWER PLUS (WITH MYCORRHIZAE)' AT A RATE OF 15LBS PER CU. YD.
- 15. THE CONTRACTOR SHALL MAINTAIN THE INSTALLED LANDSCAPE FOR A PERIOD OF 90 DAYS BEGINNING ON THE DATE OF FINAL ACCEPTANCE.
- 16. AT THE END OF THE <u>90 DAY MAINTENANCE</u> AND PLANT ESTABLISHMENT PERIOD ALL PLANTING AREAS SHALL BE TREATED WITH POST PLANTING FERTILIZER 'GRO-POWER CONTROLLED RELEASE 12-8-8' AT A RATE OF 15LBS PER 1,000 SQ. FT.
- 17. ALL LANDSCAPE AND IRRIGATION SHALL CONFORM TO THE STANDARDS OF THE CITY-WIDE LANDSCAPE REGULATIONS AND THE CITY OF PLACERVILLE DEVELOPMENT GUIDE AND ALL OTHER LANDSCAPE RELATED CITY AND REGIONAL STANDARDS.
- 18. EXISTING TREES TO REMAIN ON SITE WITHIN THE AREA OF WORK WILL BE PROTECTED IN PLACE. THE FOLLOWING PROTECTION MEASURES WILL BE PROVIDED:
 - A. A BRIGHT YELLOW OR ORANGE TEMPORARY FENCE WILL BE PLACED AROUND EXISTING TREES AT THE DRIP LINE.

 B. STOCKPILING, TOPSOIL DISTURBANCE, VEHICLE US, AND MATERIAL
- STORAGE OF ANY KIND IS PROHIBITED WITHIN THE DRIP LINE.

 C. A TREE WATERING SCHEDULE WILL BE MAINTAINED AND DOCUMENTED DURING CONSTRUCTION.
- D. ALL DAMAGED TREES WILL BE REPLACED WITH ONE OF EQUAL OR GREATER SIZE.
- 19. MULCH: ALL REQUIRED PLANTING AREAS AND ALL EXPOSED SOIL AREAS WITHOUT VEGETATION SHALL BE COVERED WITH MULCH TO A MINIMUM DEPTH OF 3 INCHES, EXCLUDING SLOPES REQUIRING REVEGETATION.
- 20. TREE ROOT BARRIERS SHALL BE INSTALLED WHERE TREES ARE PLACED WITHIN 5 FEET OF PUBLIC IMPROVEMENTS INCLUDING WALKS, CURBS, OR STREET PAVEMENTS OR WHERE NEW PUBLIC IMPROVEMENTS ARE PLACED ADJACENT TO EXISTING TO EXISTING TREES. THE ROOT BARRIER WILL NOT WRAP AROUND THE ROOT BALL

LANDSCAPE
ARCHITECTURE
928 HORNBLEND STREET, SUITE #3
SAN DIEGO, CA 92109
TEL 858-274-3222 - FAX 858-274-3223

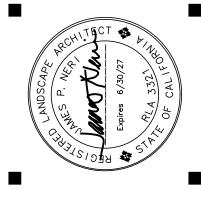

OCKINAW HOTEL

CITY SUBMITTAL

9/18/2025

LANDSCAPE PLANTING PLAN

L3.1

IRRIGATED HYDROSEED MIX SPECIES	PURE LIVE SEED LBS/ACRE
FESTUCA RUBRA	20.0
ACHILLEA MILLEFOLIUM	4.0
ESCHSCHOLZIA CALIFORNICA	8.0
PROMATRIX EFM	3,000
HYDROPOST PREMIUM COMPOST	1,000
TOTAL PURE LIVE SEED	4,032.0

INCLUDE THE FOLLOWING SLURRY COMPONENTS:

3000 LBS/ACRE FLEXTERRA HP-FGM 600 LBS/ACRE BIOSOL FORTE 7-2-1 FERTILIZER 600 LBS/ACRE AM 120 MYCORRHIZAL INOCULUM

SITE SOIL AMENDMENTS:

1. SOIL SULFUR 30LBS/ 1,000 SQ. FT. 2. SOIL CONDITIONER 4 CU. YD/ 1,000 SQ. FT. 1 QUART/ 1,000 SQ. FT. 3. WETTING AGENT: 4. GYPSUM: 50 LBS/ 1,000 SQ. FT. 100 LBS/ 1,000 SQ. FT. 5. SOIL FERTILIZER SOIL INOCULANT 20 lbs/ 1,000 sq. ft.

FERTILIZER TABLET SCHEDULE

(4) 7 GRAM TABLETS PER 6" BOX SIZE

(4) 7 GRAM TABLES PER FOOT OF PALM TRUNK

(15) 7 GRAM TABLETS PER 15 GALLON CONTAINER

(8) 7 GRAM TABLETS PER 5 GALLON CONTAINER

(3) 7 GRAM TABLETS PER 1 GALLON CONTAINER

(1) 7 GRAM TABLETS PER 6" POT, PONY PAK, LINER OR GROUNDCOVER PLANT

TREE PRESERVATION REQUIREMENTS

- A. A BRIGHT YELLOW OR ORANGE TEMPORARY FENCE WILL BE PLACED AROUND EXISTING
- C. A TREE WATERING SCHEDULE WILL BE MAINTAINED AND DOCUMENTED DURING
- D. ALL DAMAGED TREES WILL BE REPLACED WITH ONE OF EQUAL OR GREATER SIZE.

2. ROOT SYSTEMS OF EXISTING TREES ON SITE WILL BE PROTECTED FROM FLOODING, EROSION, CHEMICAL SPILLS, AND EXCESSIVE WETTING AND DRYING DURING DEWATERING.

3. THE EXISTING GRADE WILL BE MAINTAINED WITHIN THE DRIP LINE OF EXISTING TREES ON SITE.

CONSTRUCTION AND ALL CUTS WILL BE SEALED WITH WOOD PAINT AS MANUFACTURED BY FLINTKOTE OR APPROVED EQUAL.

5. MAINTAIN AND DOCUMENT A TREE WATERING SCHEDULE DURING CONSTRUCTION.

THE SAME SPECIES.

THE FOLLOWING PROTECTION FOR EXISTING TREES TO REMAIN ON SITE WILL BE PROVIDED:


1. EXISTING TREES TO REMAIN ON SITE WITHIN THE AREA OF WORK WILL BE PROTECTED IN PLACE. THE FOLLOWING PROTECTION MEASURES WILL BE PROVIDED:


- TREES AT THE DRIP LINE. B. STOCKPILING, TOPSOIL DISTURBANCE, VEHICLE US, AND MATERIAL STORAGE OF ANY KIND IS
- PROHIBITED WITHIN THE DRIP LINE.


4. ROOTS OF EXISTING TREES ON SITE WILL BE CUT APPROXIMATELY 6 INCHES BACK FROM NEW

6. ALL DAMAGED TREES WILL BE REPLACED WITH A MINIMUM 36" BOX OR GREATER SIZE TREE OF


SYMBOL	DESCRIPTION	MANUF. & MODEL	MATERIAL & SIZE	NOTES	DETAIL
P42	42" SQUARE	CHANDLER COMPANY STYLE: CONTEMPORARY	42"L X 42"W X 42"H	TEXTURE: SMOOTH COLOR: SLATE (SEND SAMPLE TO ARCH FOR APPROVAL PRIOR TO <u>ORDERING</u>) IRRIGATION: 'MONA TANK' SYSTEM, MTS TANK 6 NO FACTORY DRAIN HOLES INSTALL ALL PLANTERS EXACTLY LEVEL SOIL: AMENDED BACKFILL PER SPECIFICATIONS	D/ L204

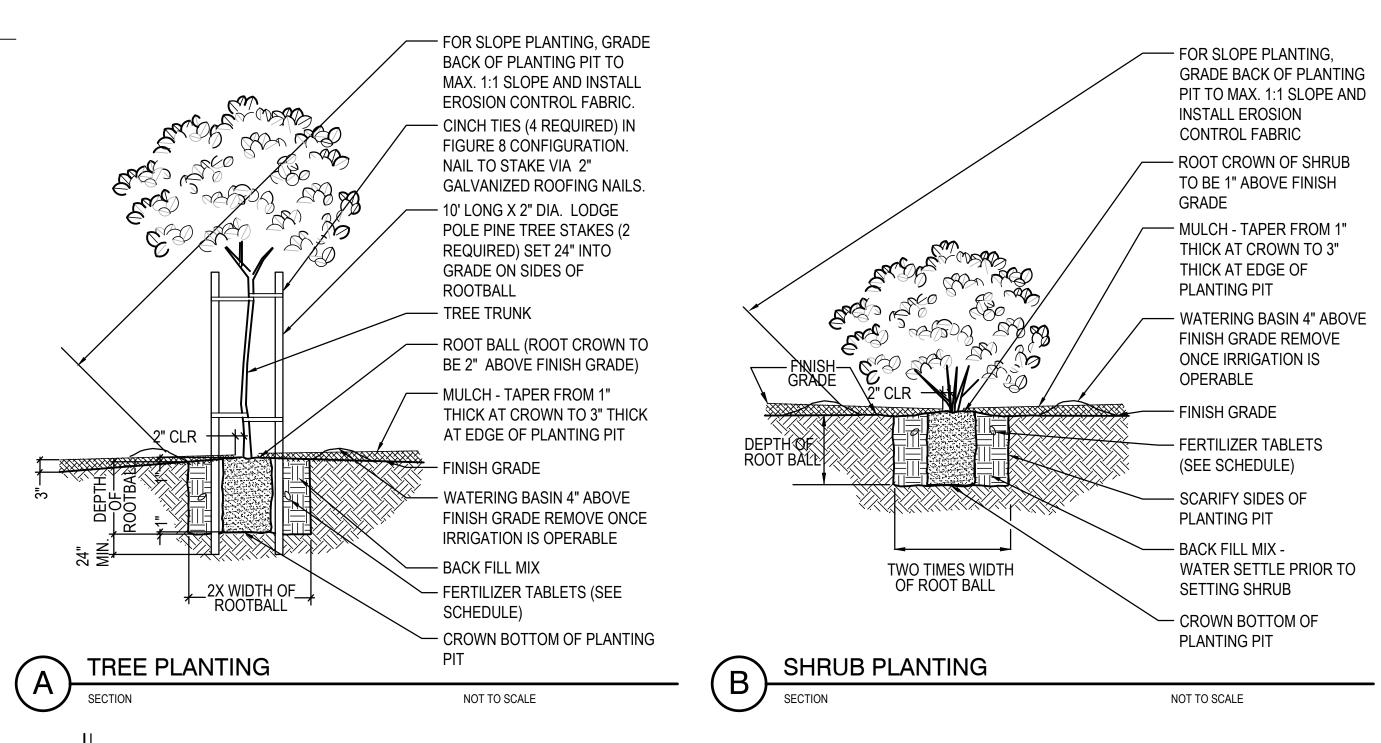


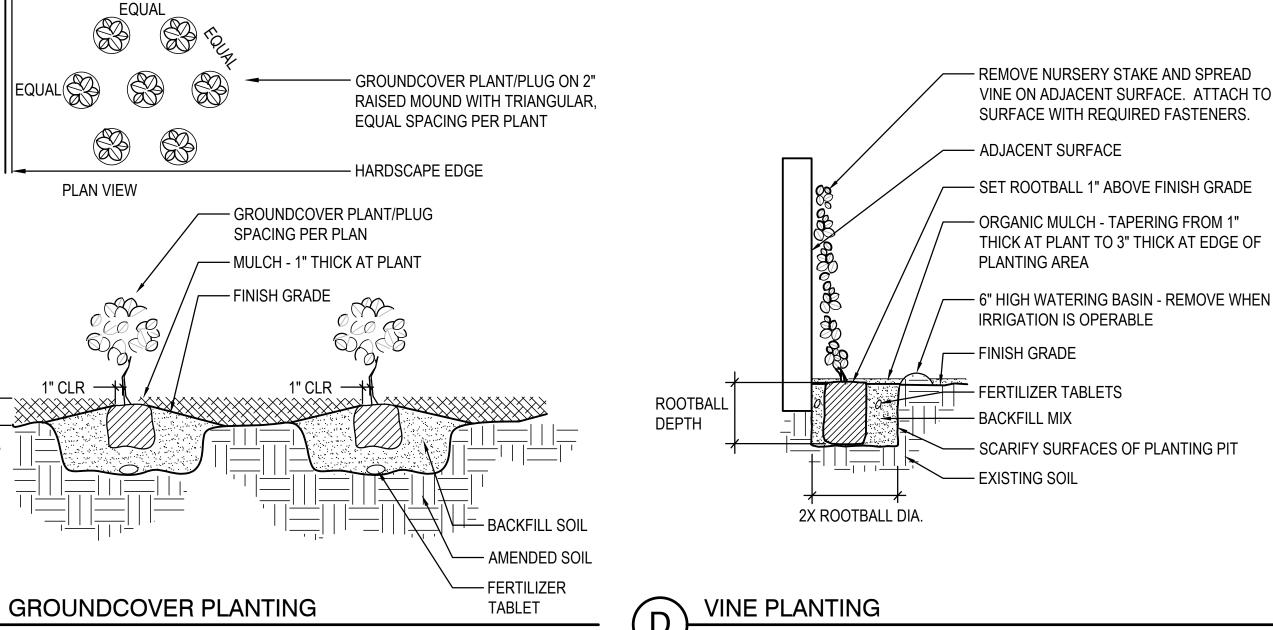

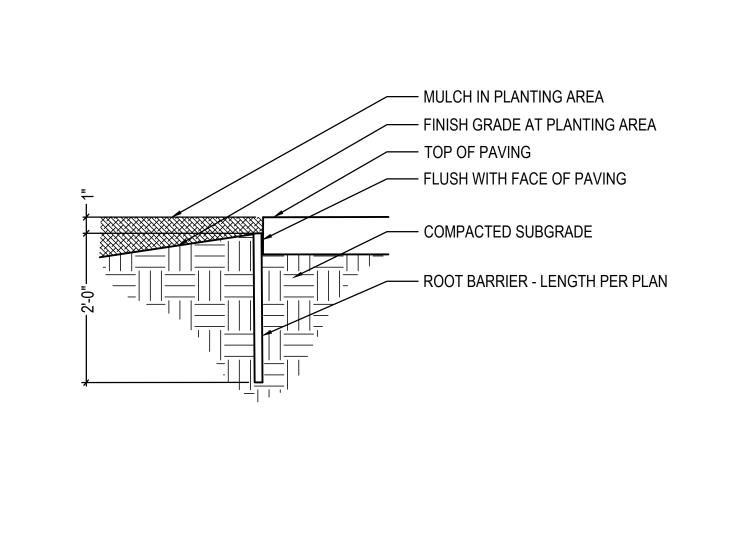

NOT TO SCALE

 

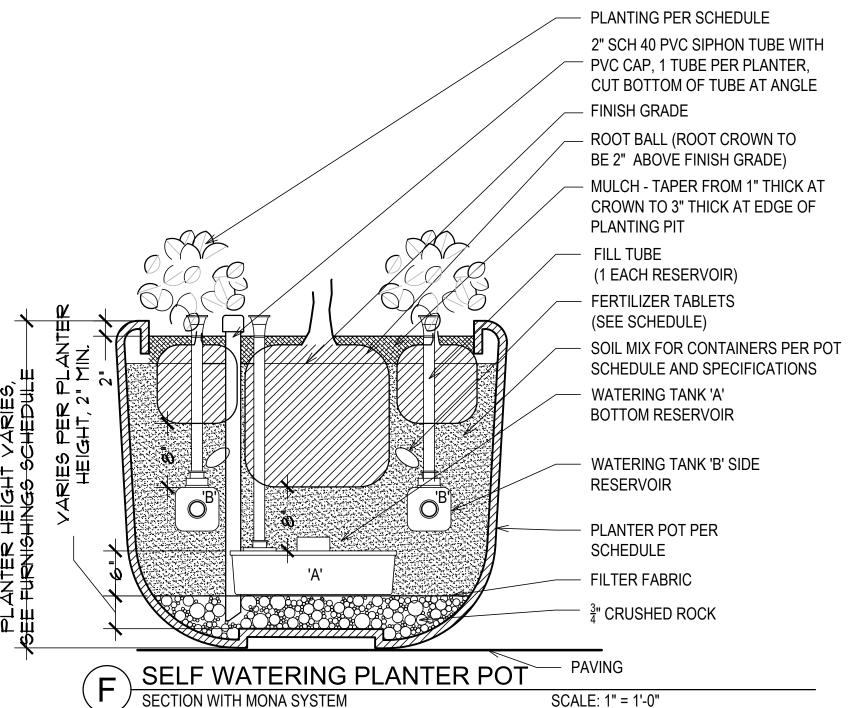

NOT TO SCALE

CKINAW

CITY SUBMITTAL

9/18/2025

PLANTING SCHEDULE, TAILS & NOT

- **-**

SHADING CALCULATIONS:

35 FEET DIAMETER TREES AT 15 YEARS: 100% = 962 SQUARE FEET; 75% = 722 SQUARE FEET; 50% = 481 SQUARE FEET; 25% = 240 SQUARE FEET 30 FEET DIAMETER TREES AT 15 YEARS: 100% = 706 SQUARE FEET; 75% = 530 SQUARE FEET; 50% = 354 SQUARE FEET; 25% = 177 SQUARE FEET 25 FEET DIAMETER TREES AT 15 YEARS: 100% = 491 SQUARE FEET; 75% = 368 SQUARE FEET; 50% = 246 SQUARE FEET; 25% = 123 SQUARE FEET


SHADED CALCULATION TABLE

	CALCULATION TABLE	1	T			
SYM	BOTANICAL NAME/ COMMON NAME	CANOPY QUANTITY @ FULL SHADE	CANOPY QUANTITY @ 3/4 SHADE	CANOPY QUANTITY @ 1/2 SHADE	CANOPY QUANTITY @ 1/4 SHADE	TOTAL SQUARE FEET
T1	QUERCUS WISLIZENI / INTERIOR LIVE OAK (35' DIA. TREE AT 15 YEARS)	9 @ 962 S.F.= 8,658 S.F.	3 @ 722 S.F. = 2,166 S.F.	14 @ 481 S.F.= 6,734 S.F.	4 @ 240 S.F. = 960 S.F.	18,518 S.F.
T2	SEQUOIA SEMPERVIRENS/ CALIFORNIA REDWOOD (30' DIA. TREE AT 15 YEARS)	5 @ 706 S.F.= 3,530 S.F.		6 @ 530 S.F.= 3,180 S.F.	3 @ 177 S.F. = 531 S.F.	7,241 S.F.
Т3	CORNUS NUTTALII/ PACIFIC DOGWOOD (25' DIA. TREE @ 15 YEARS)			2 @ 256 S.F.= 512 S.F.		512 S.F.
	•	•			TOTAL	26,244 S.F.

TOTAL PARKING LOT PAVED AREA:	44,989 F
TOTAL TREE SHADE REQUIRED (50%):	22,495 SF
TOTAL TREE SHADE PROVIDED:	26,244 S.F.
PERCENT SHADED RPROVIDED:	58 %

Drawn -Checked - JPN

ERI ANDSCAPE IRCHITECTURE 3 HORNBLEND STREET, SUITE #3 8 HORNBLEND STREET, SUITE #3

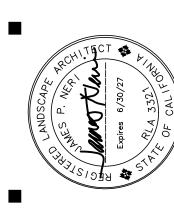

LANDSCAPE DESIGN PLAN FOR
MACKINAW HOTE

CITY SUBMITTAL

9/18/2025

PARKING LOT SHADING PLAN

L3.3